






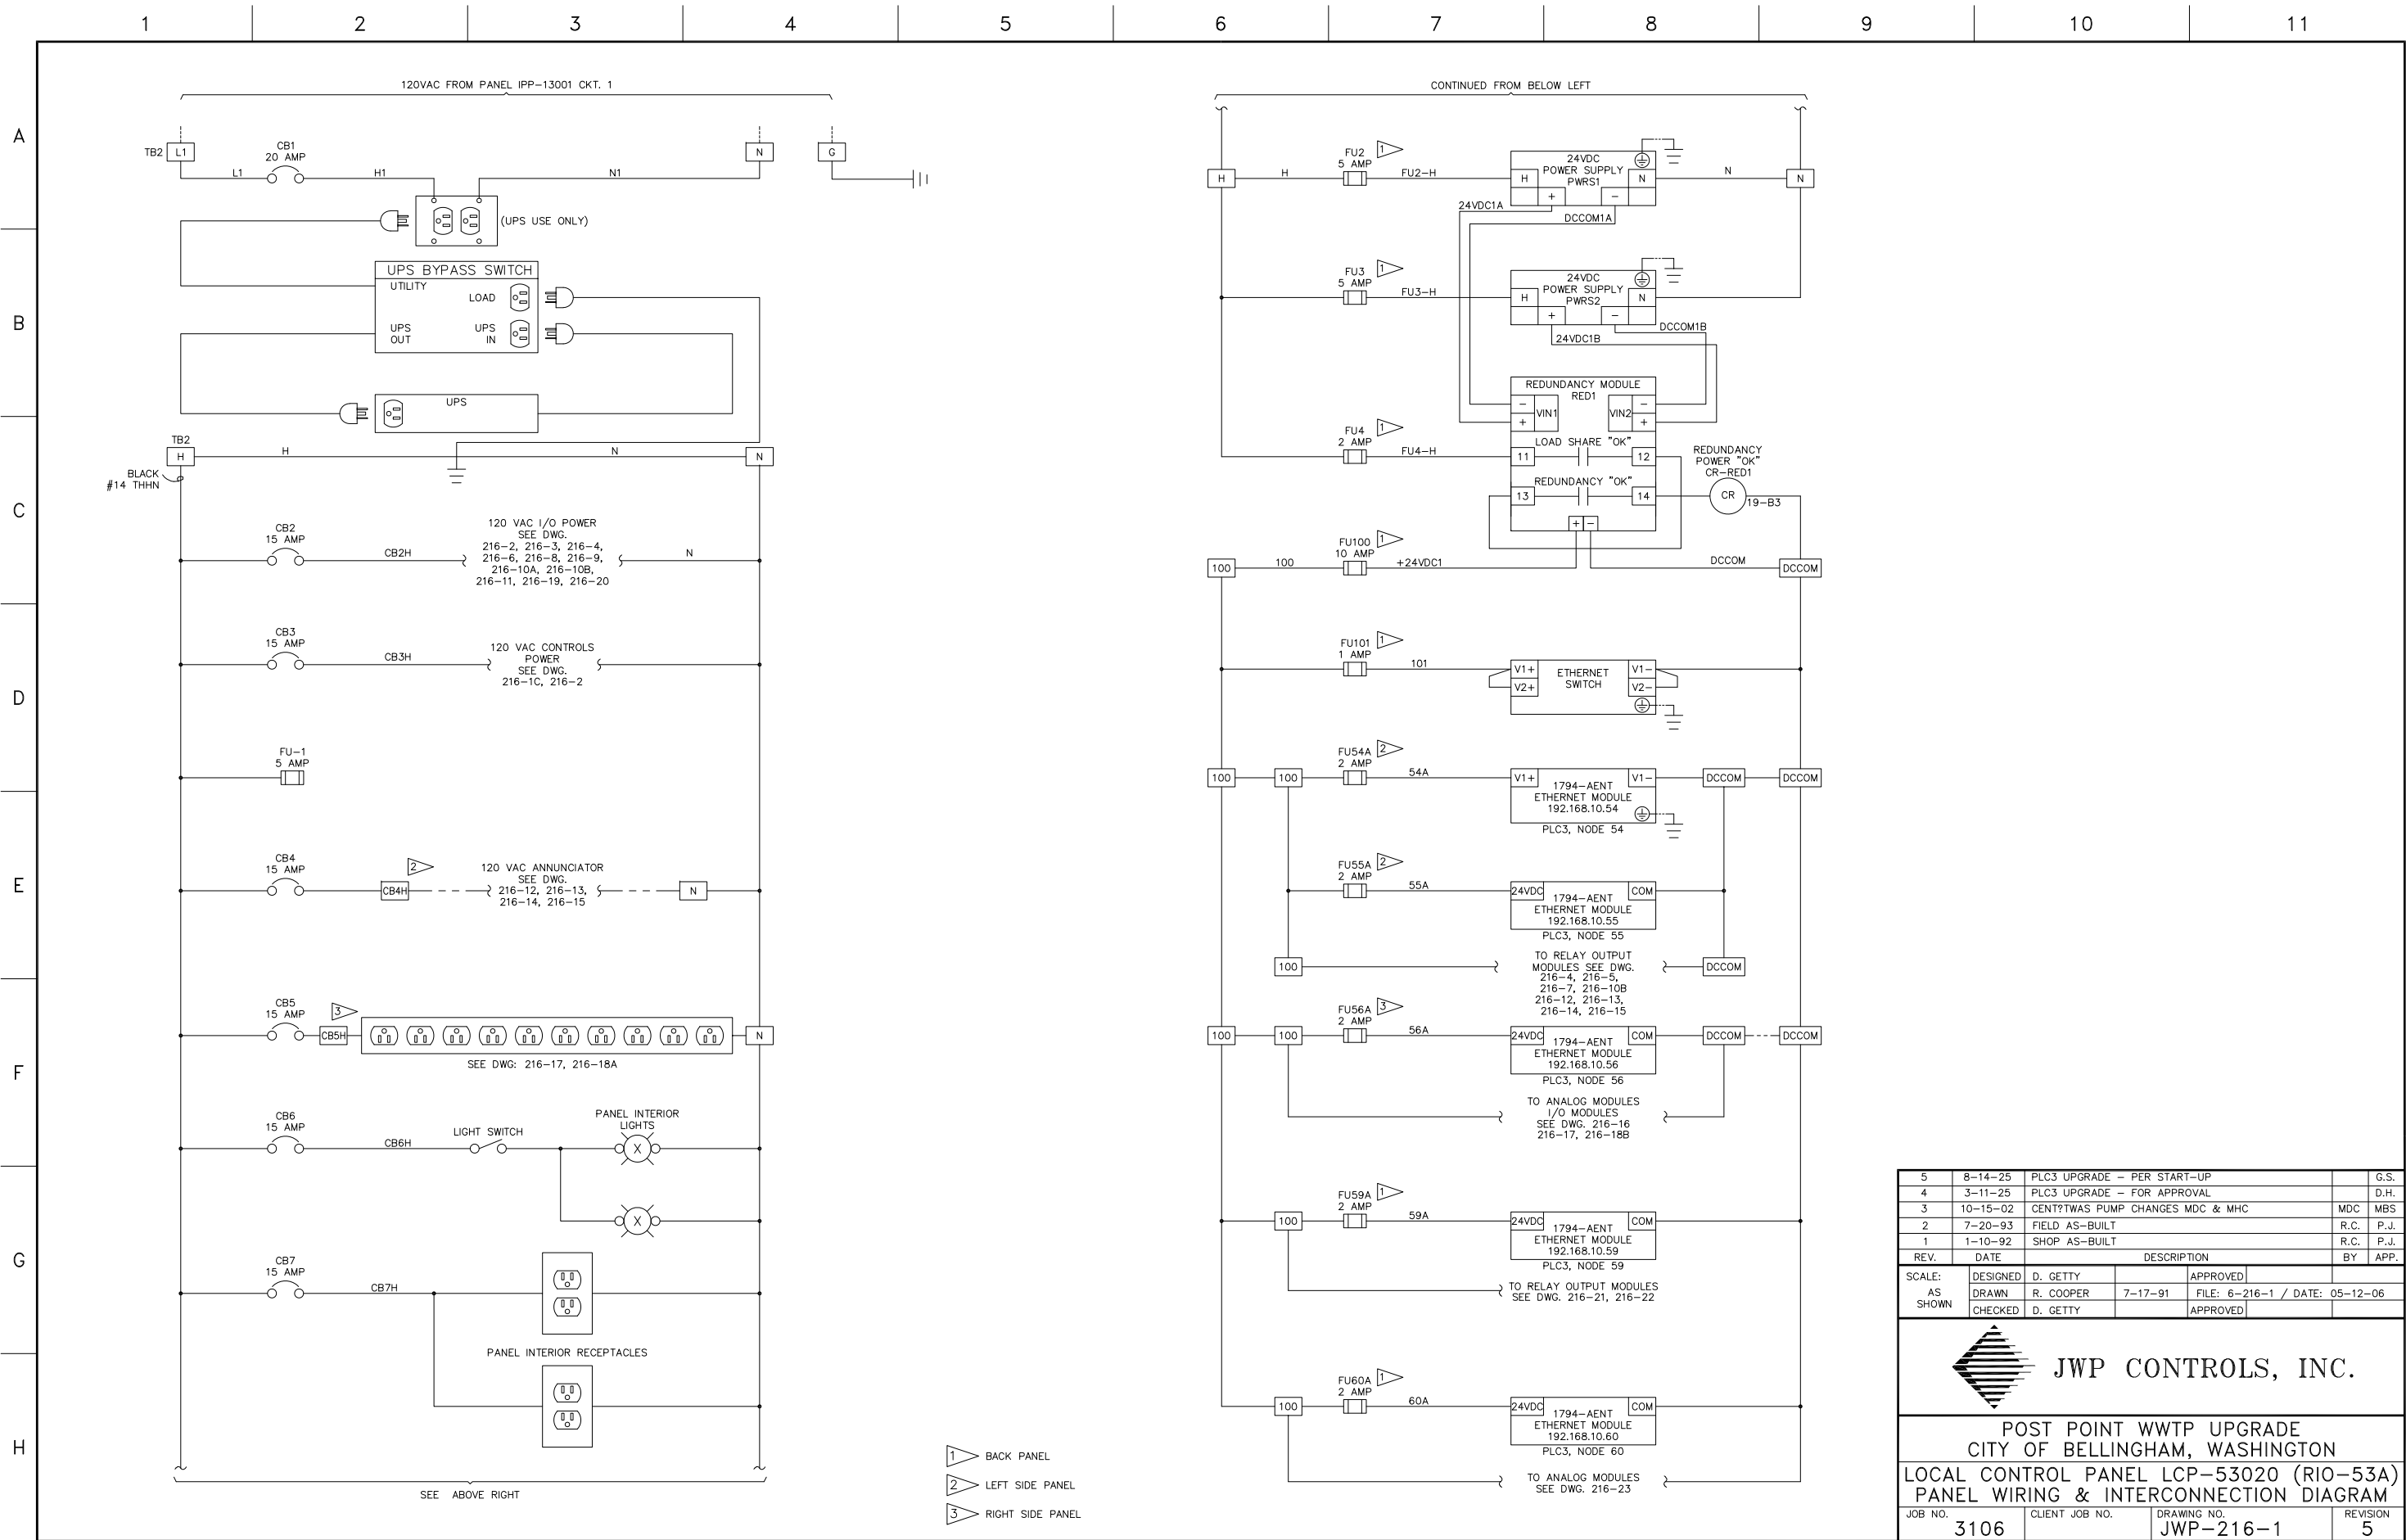


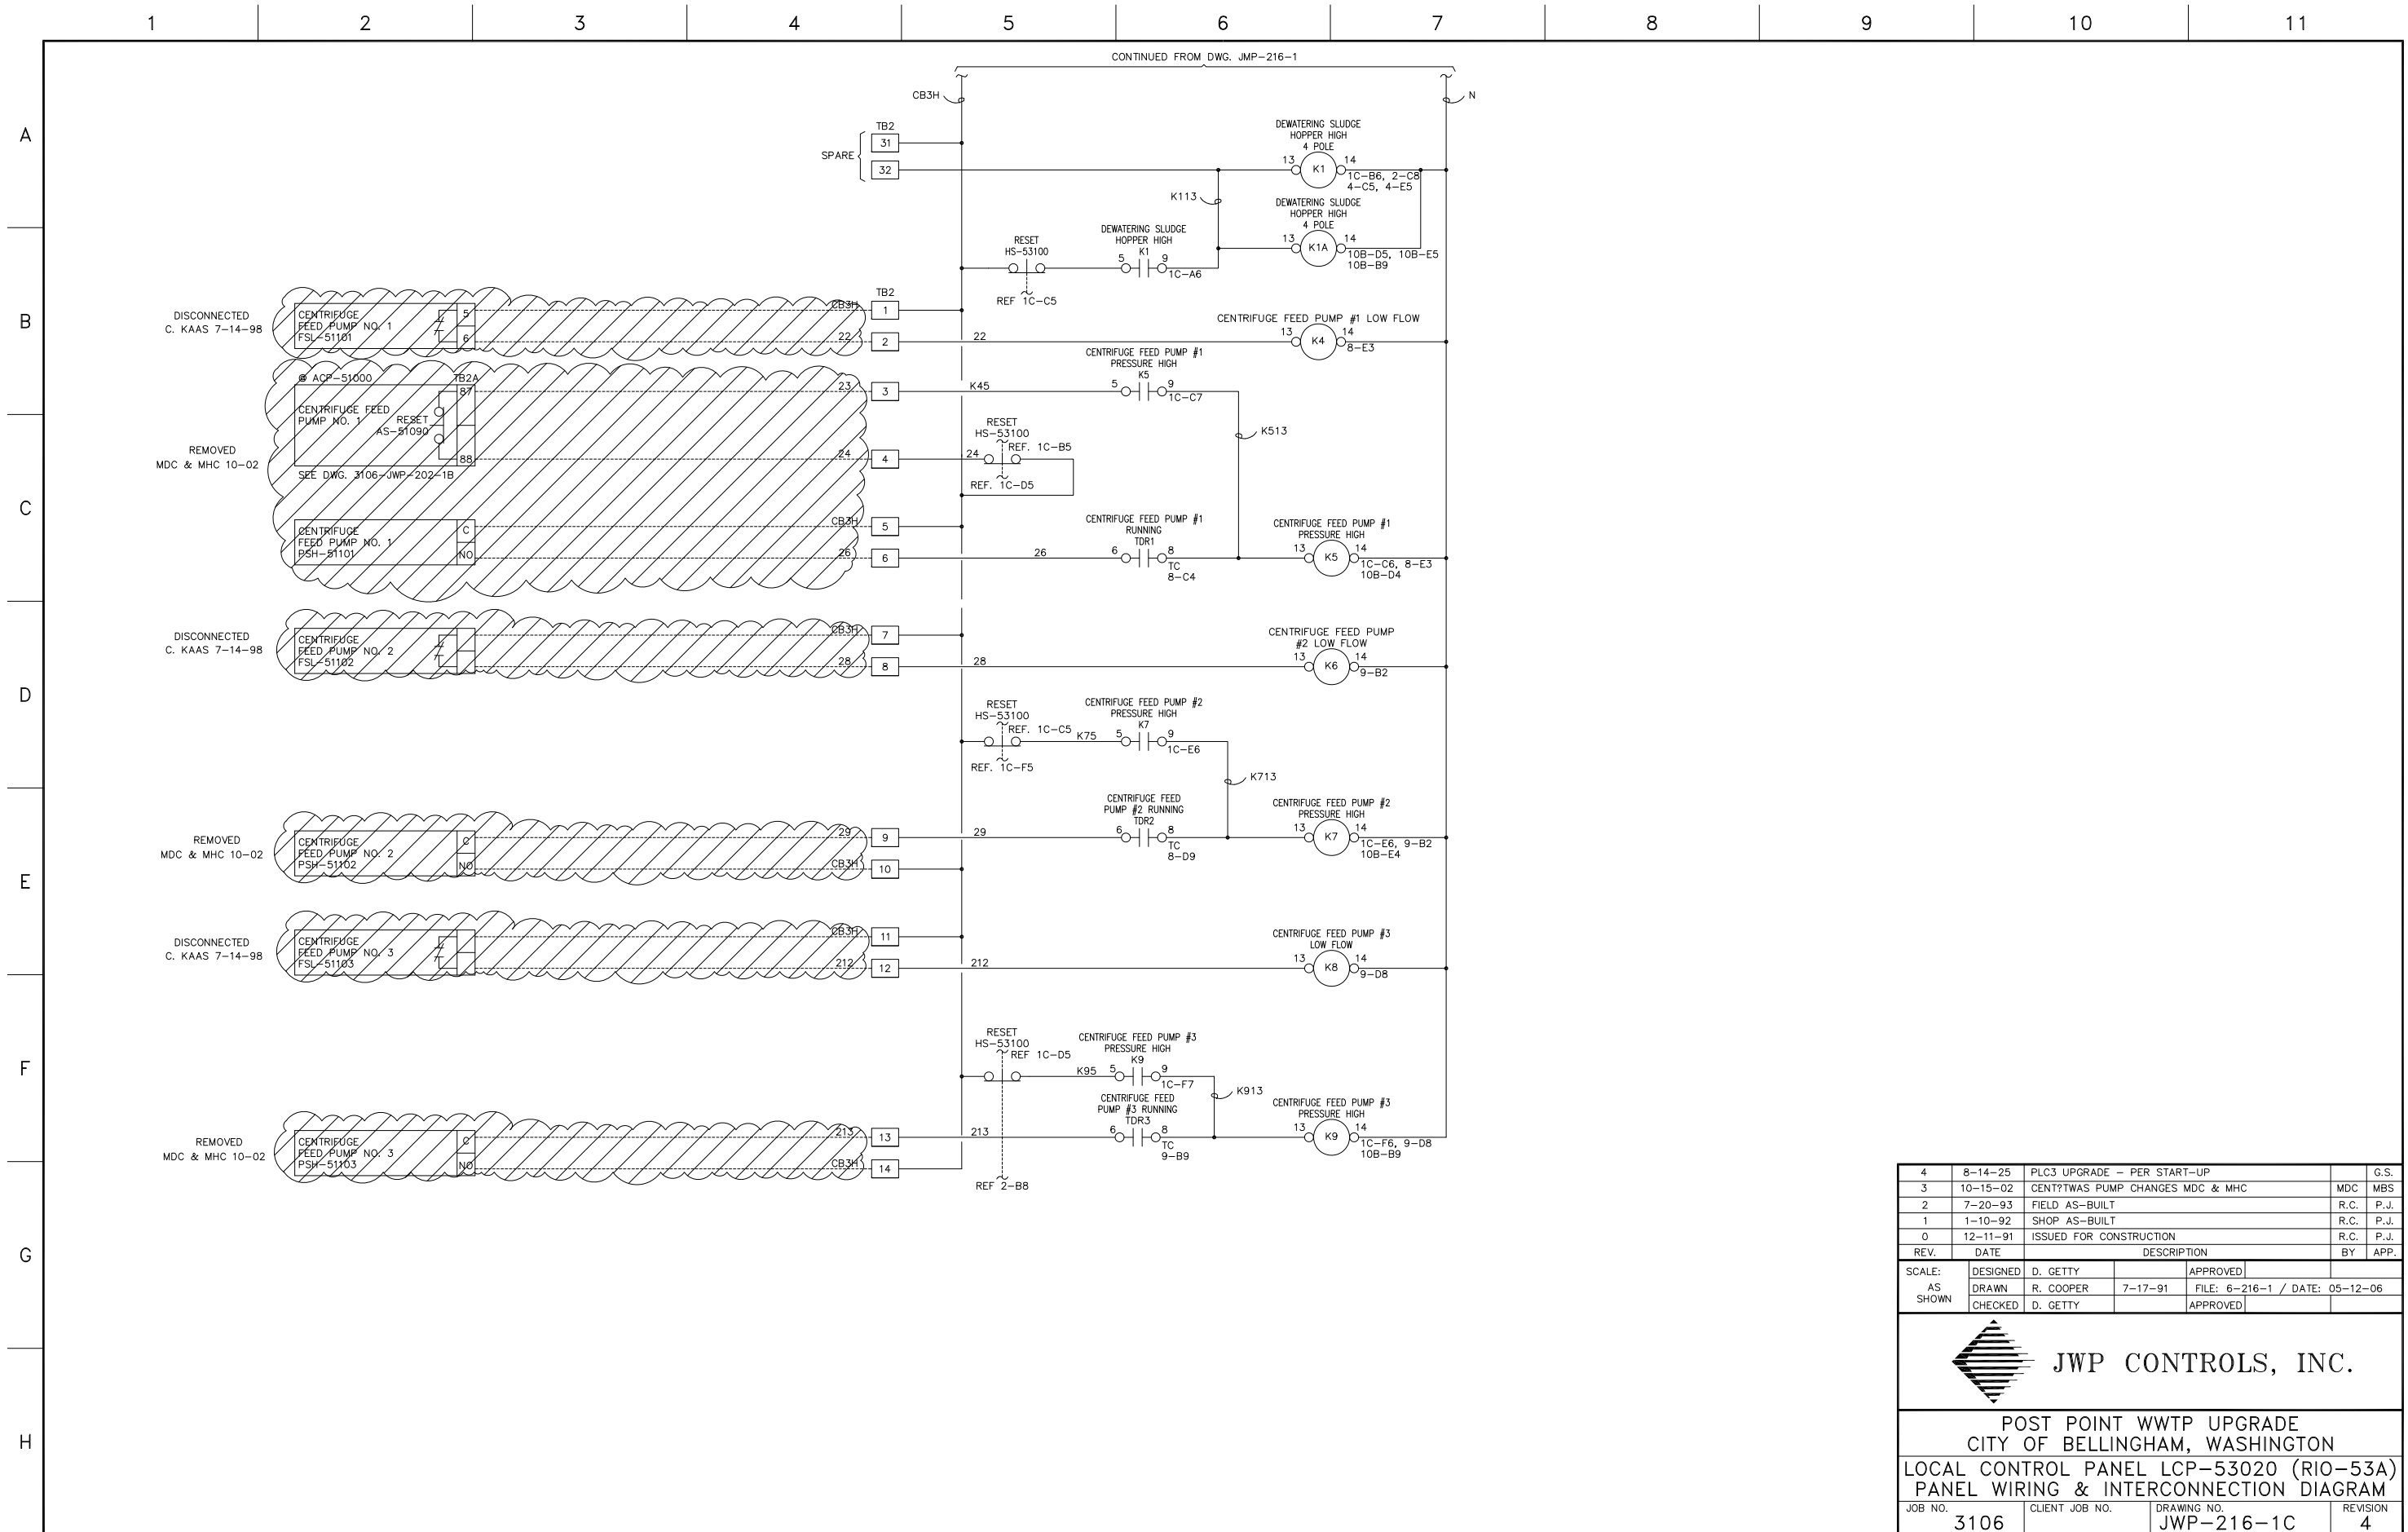


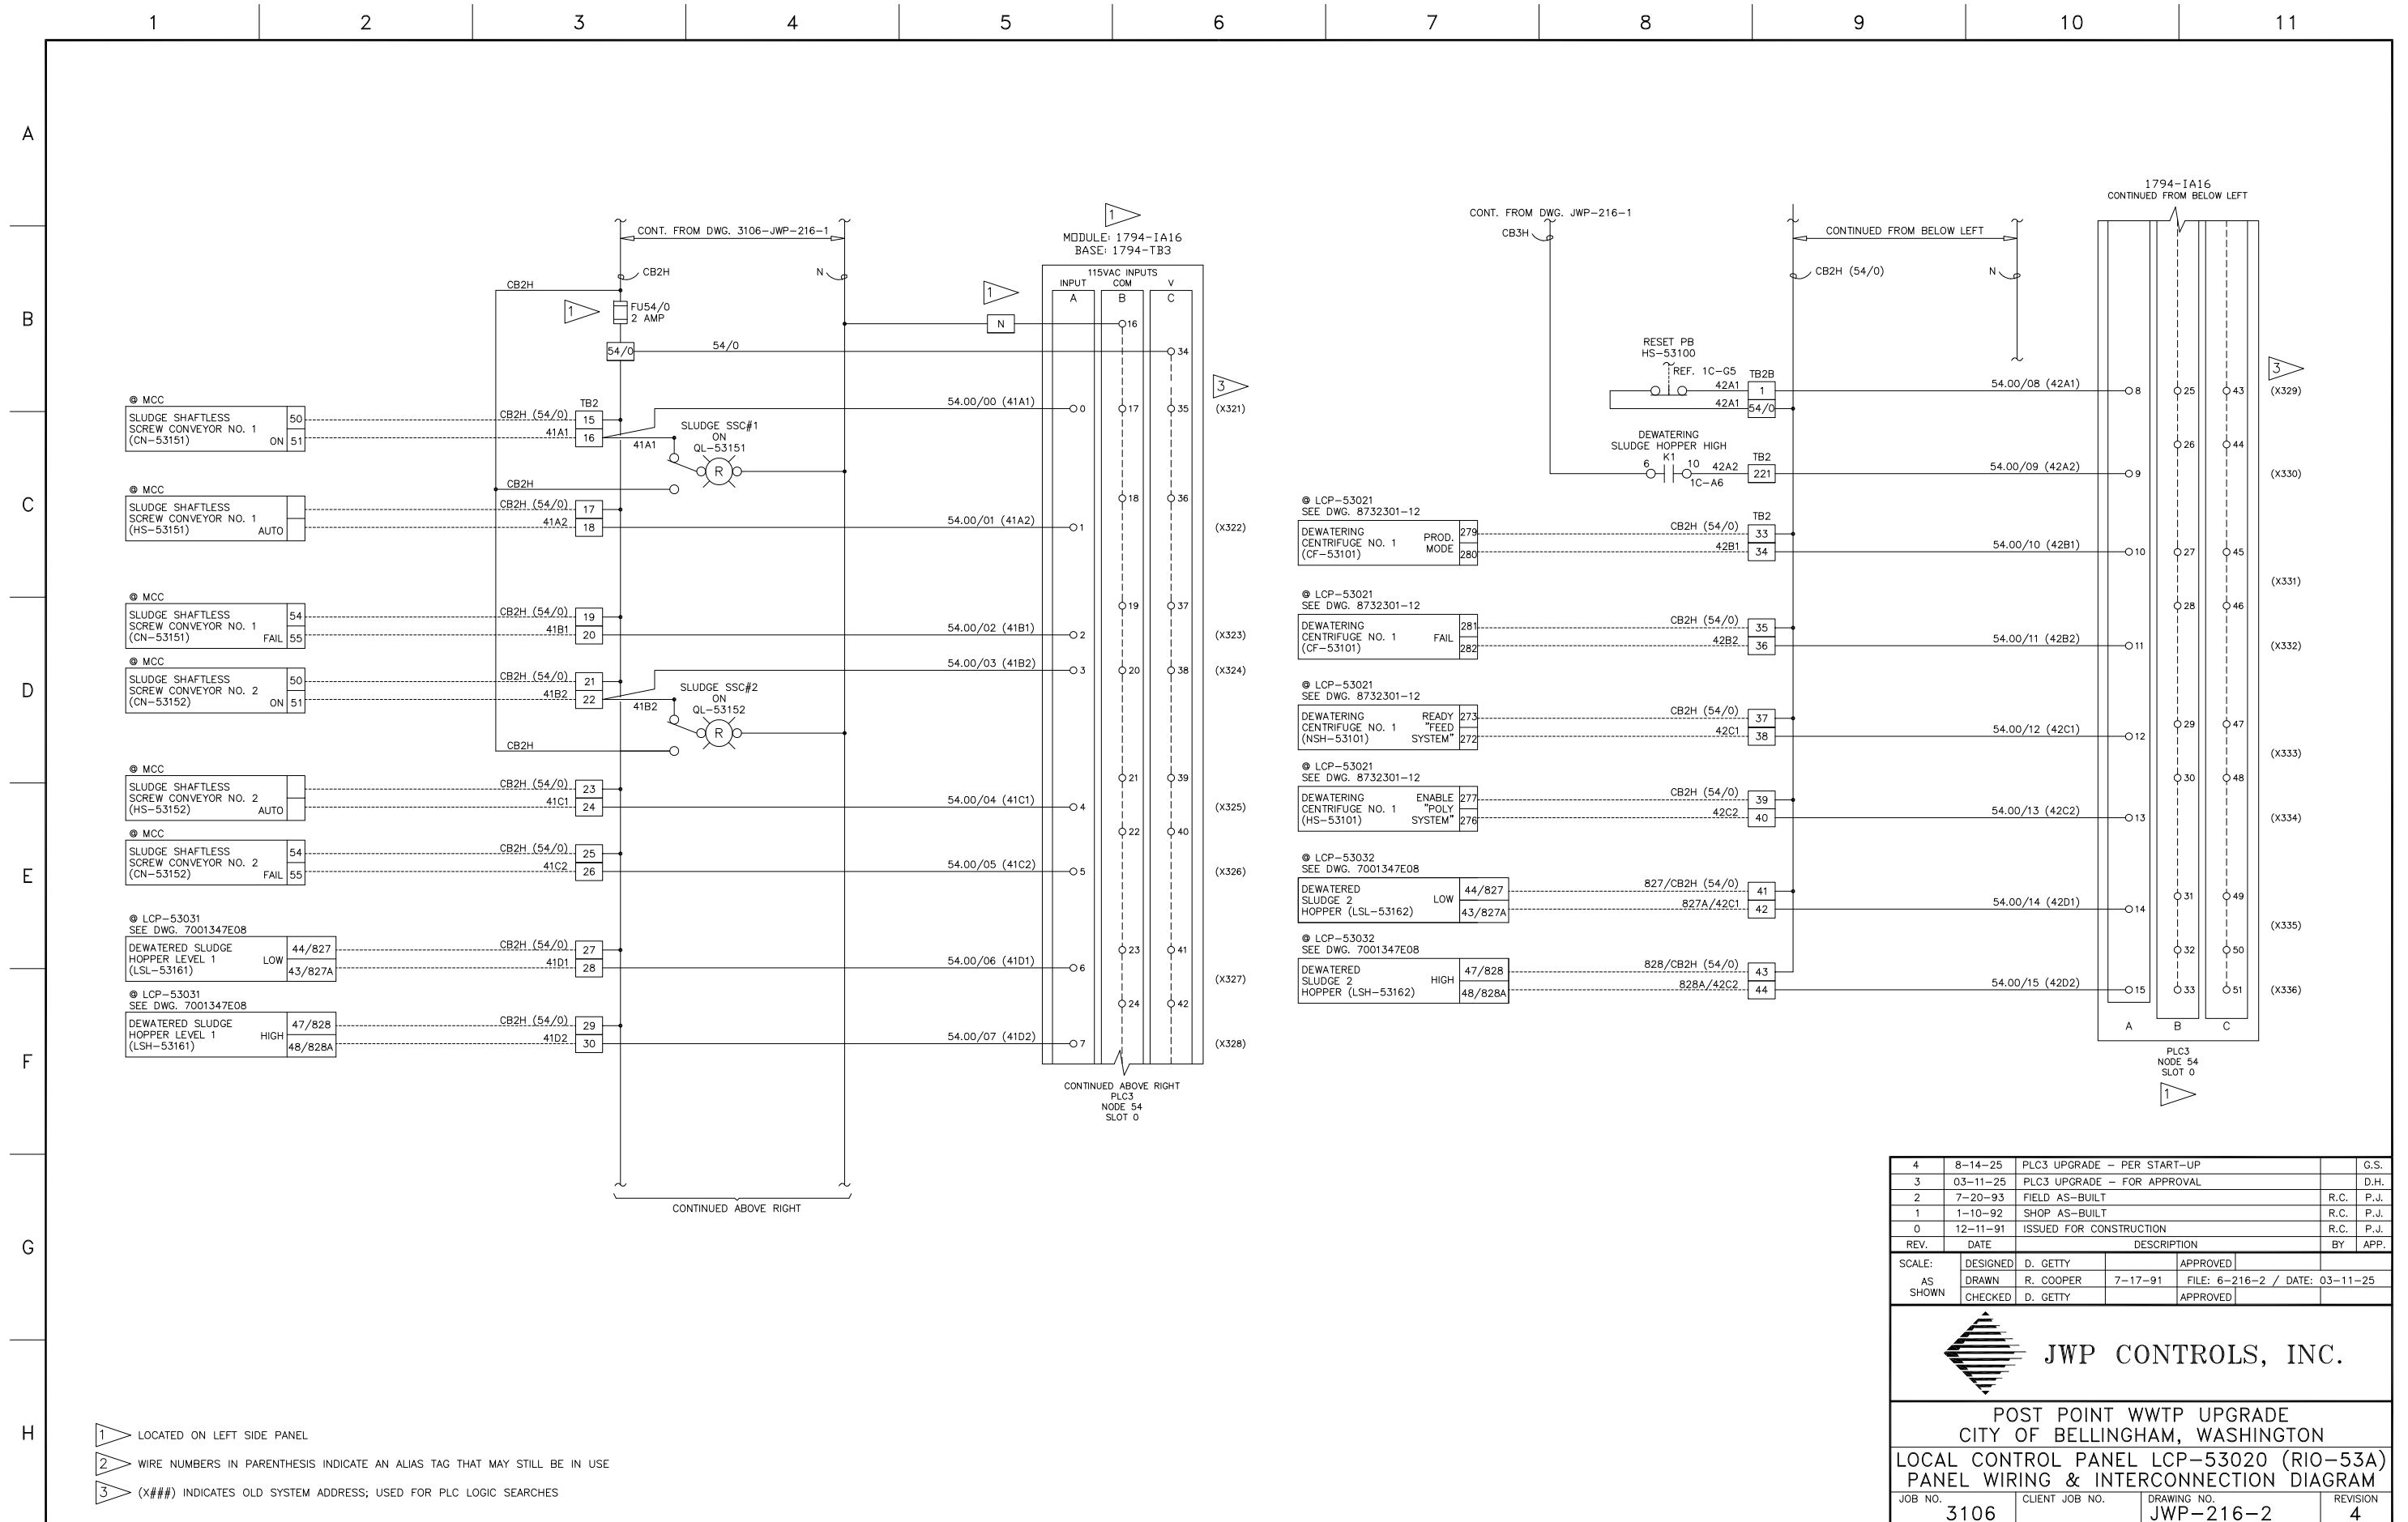


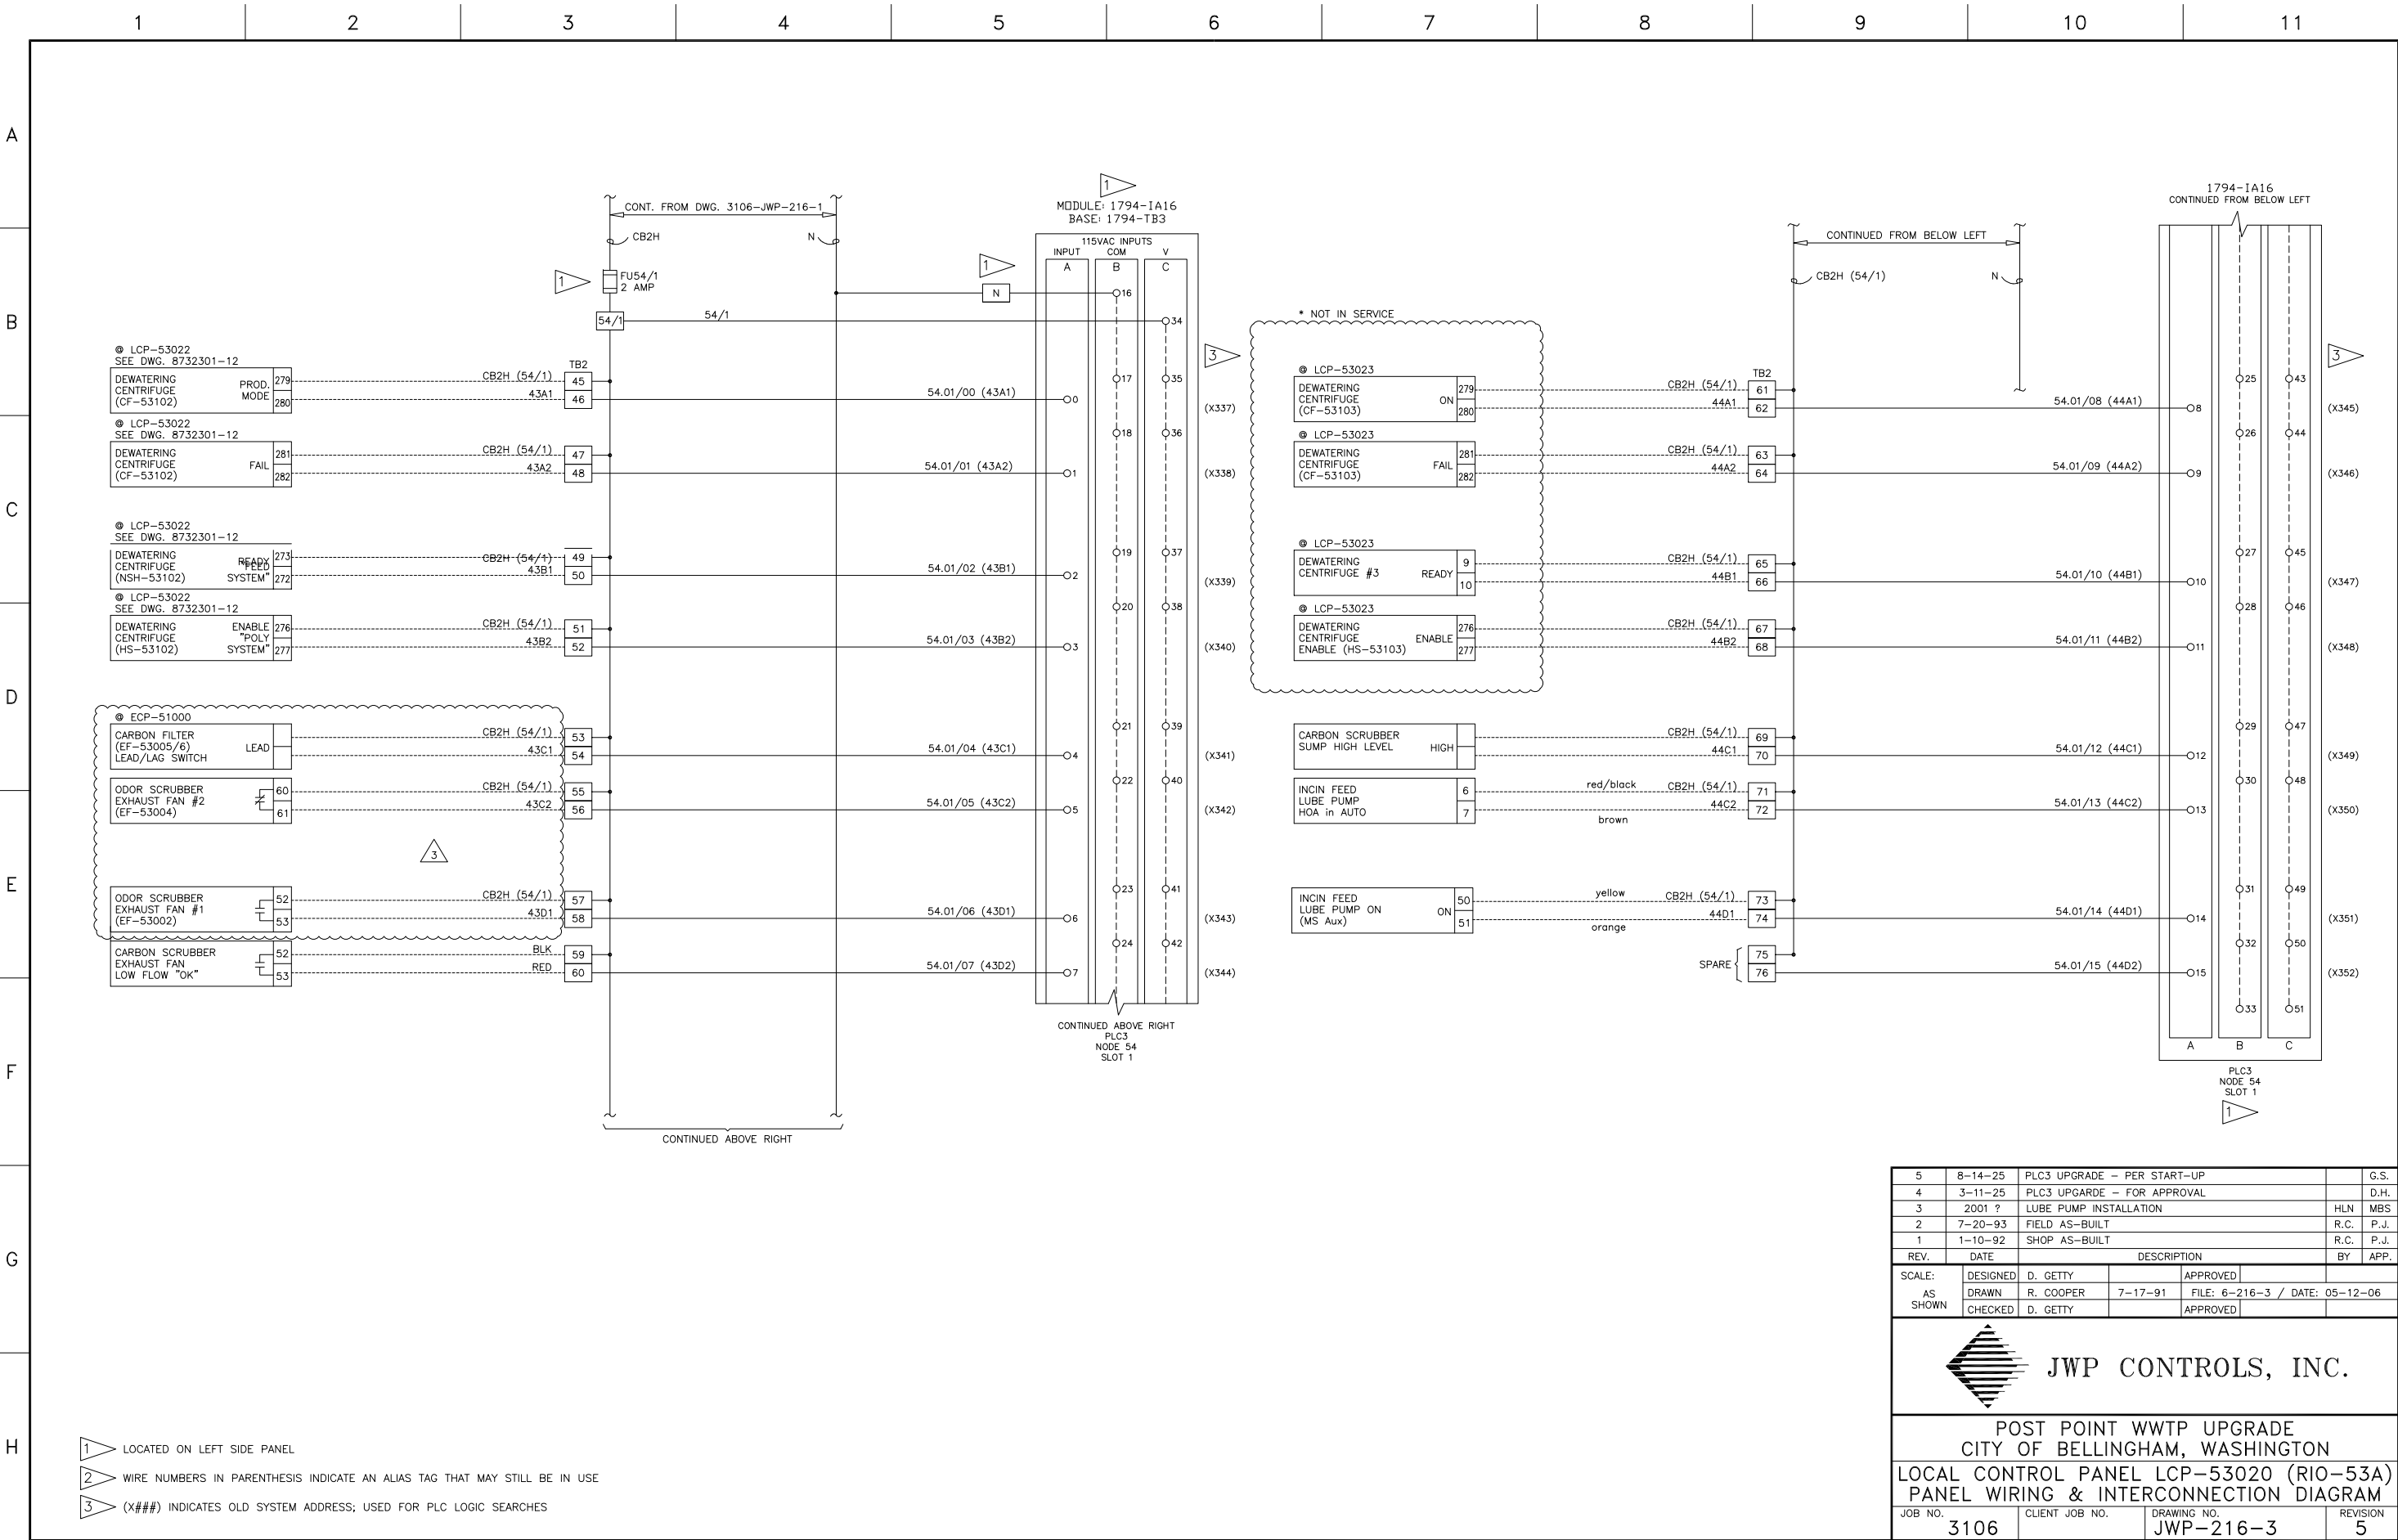


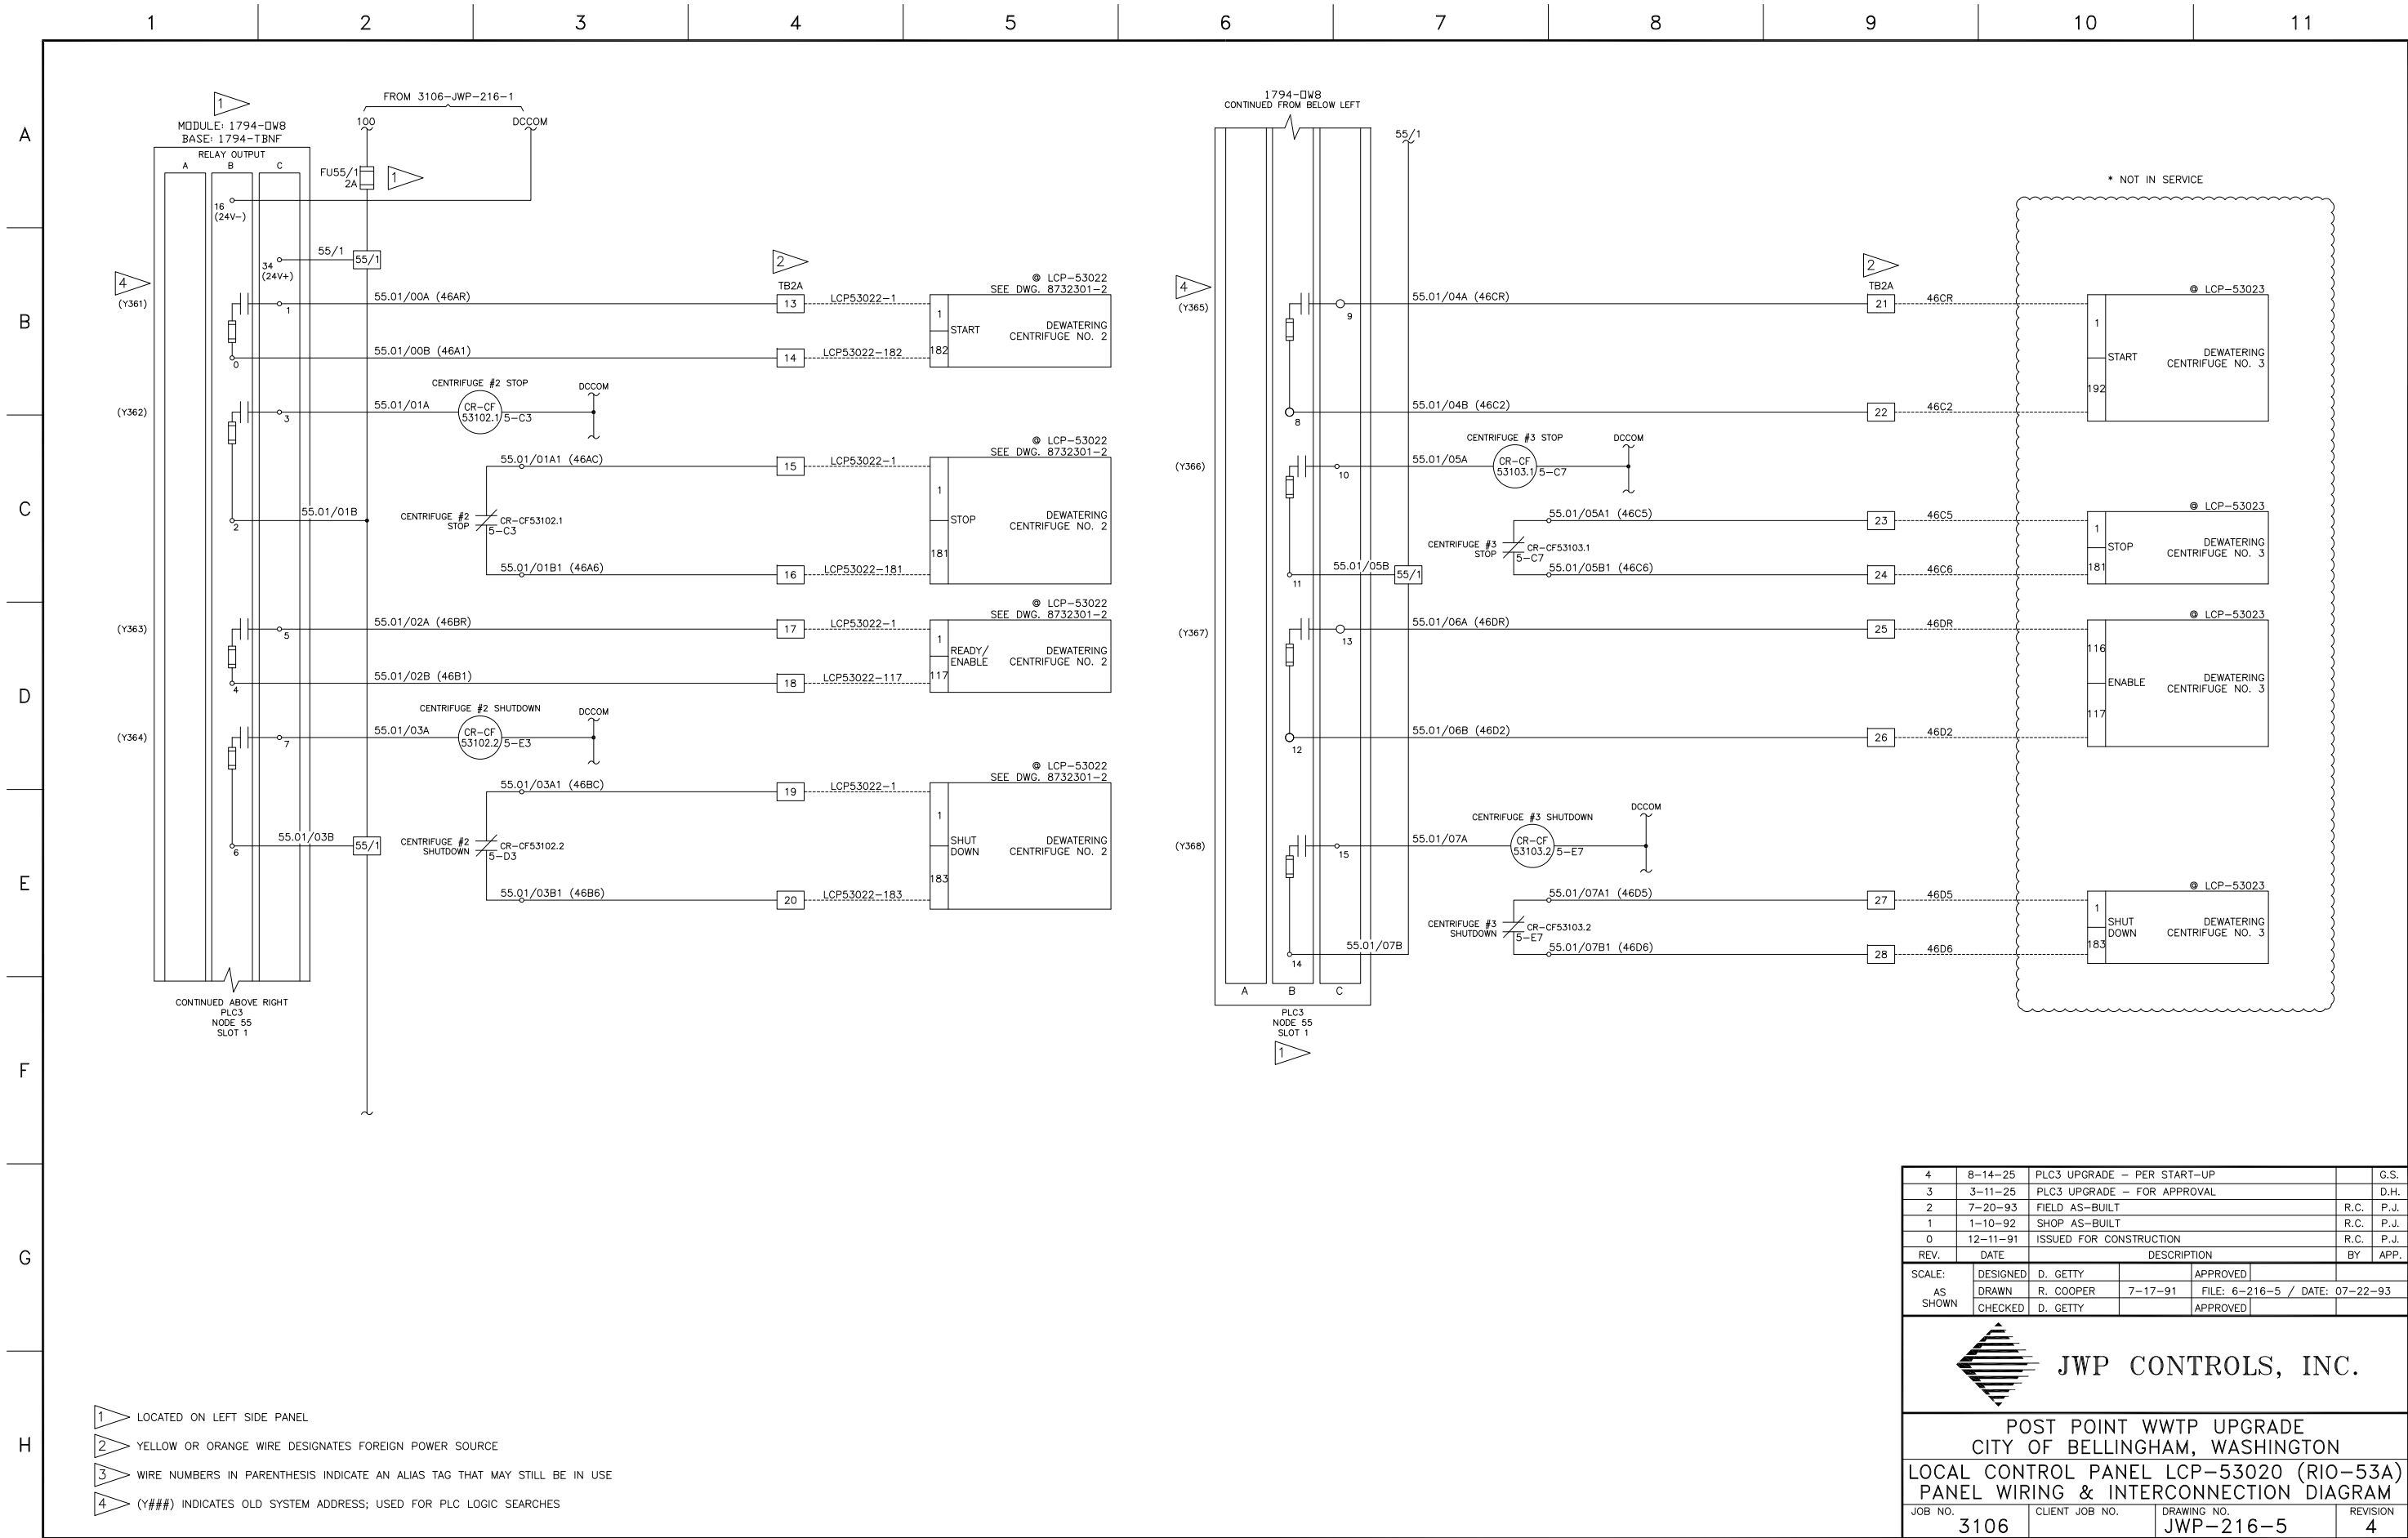


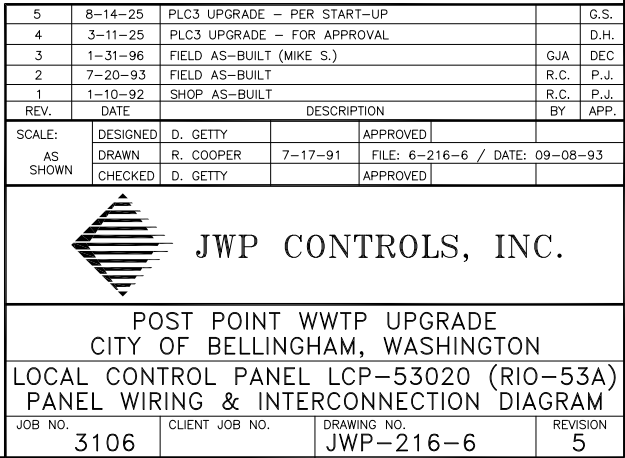


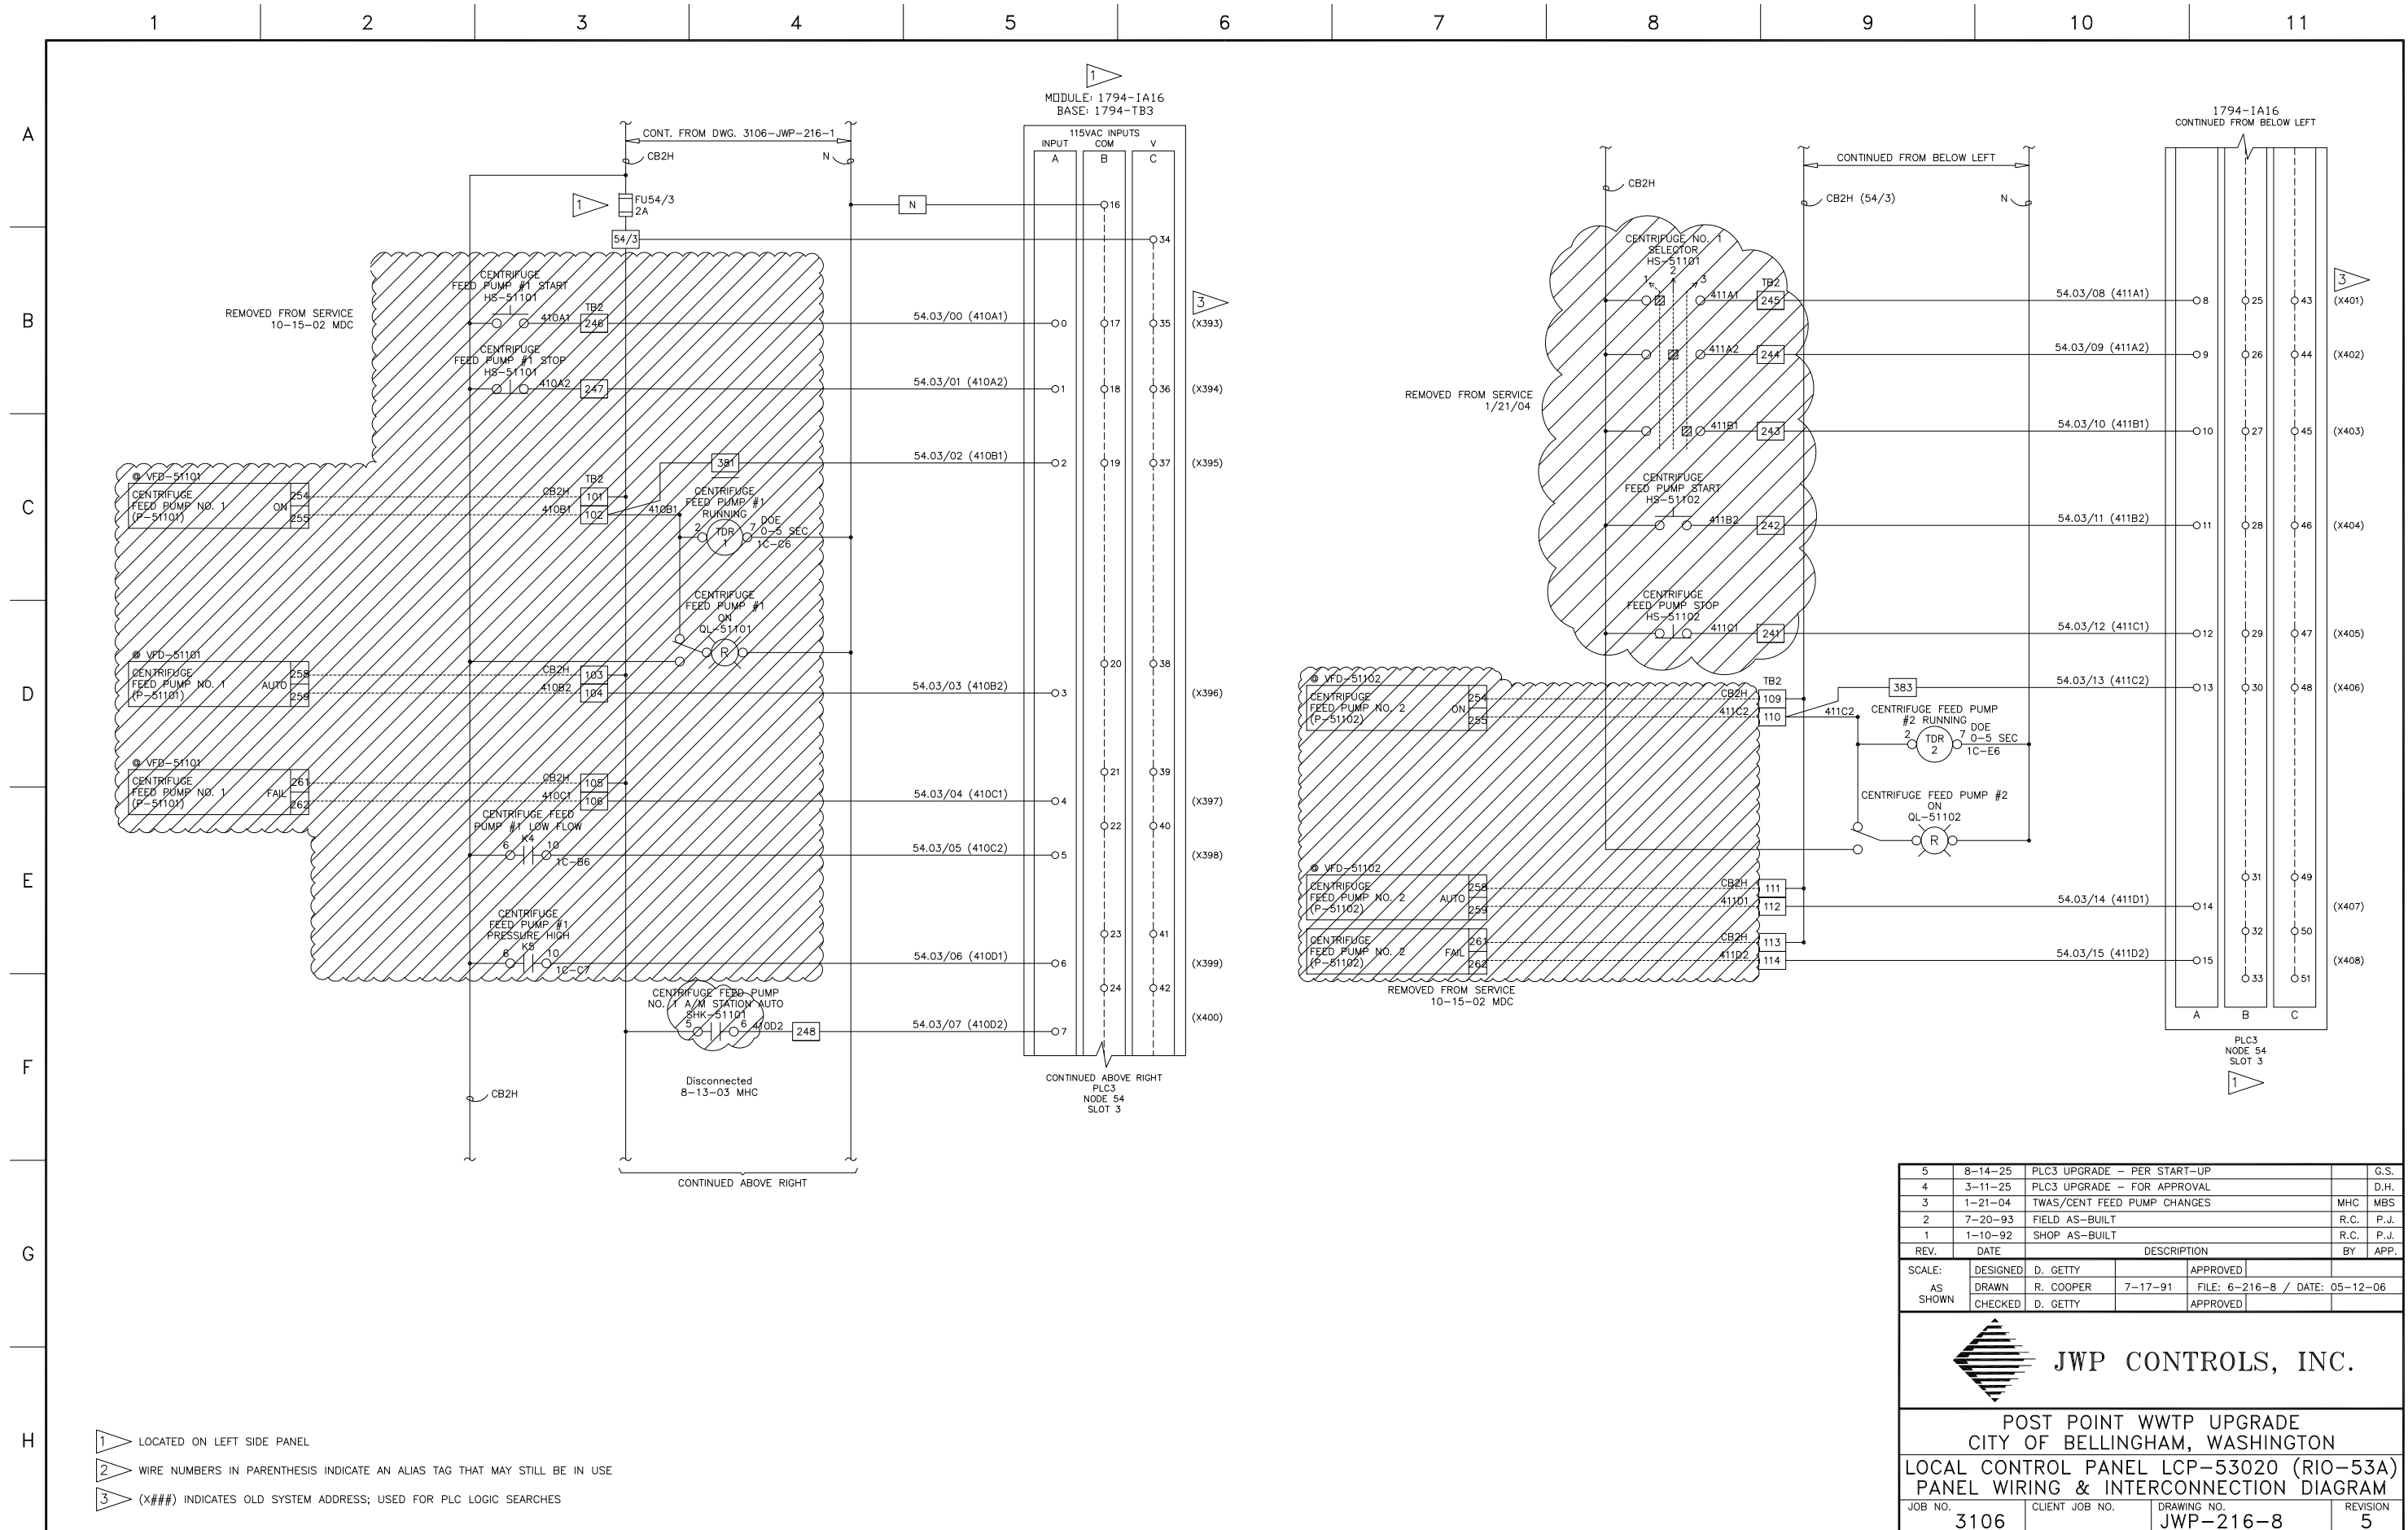

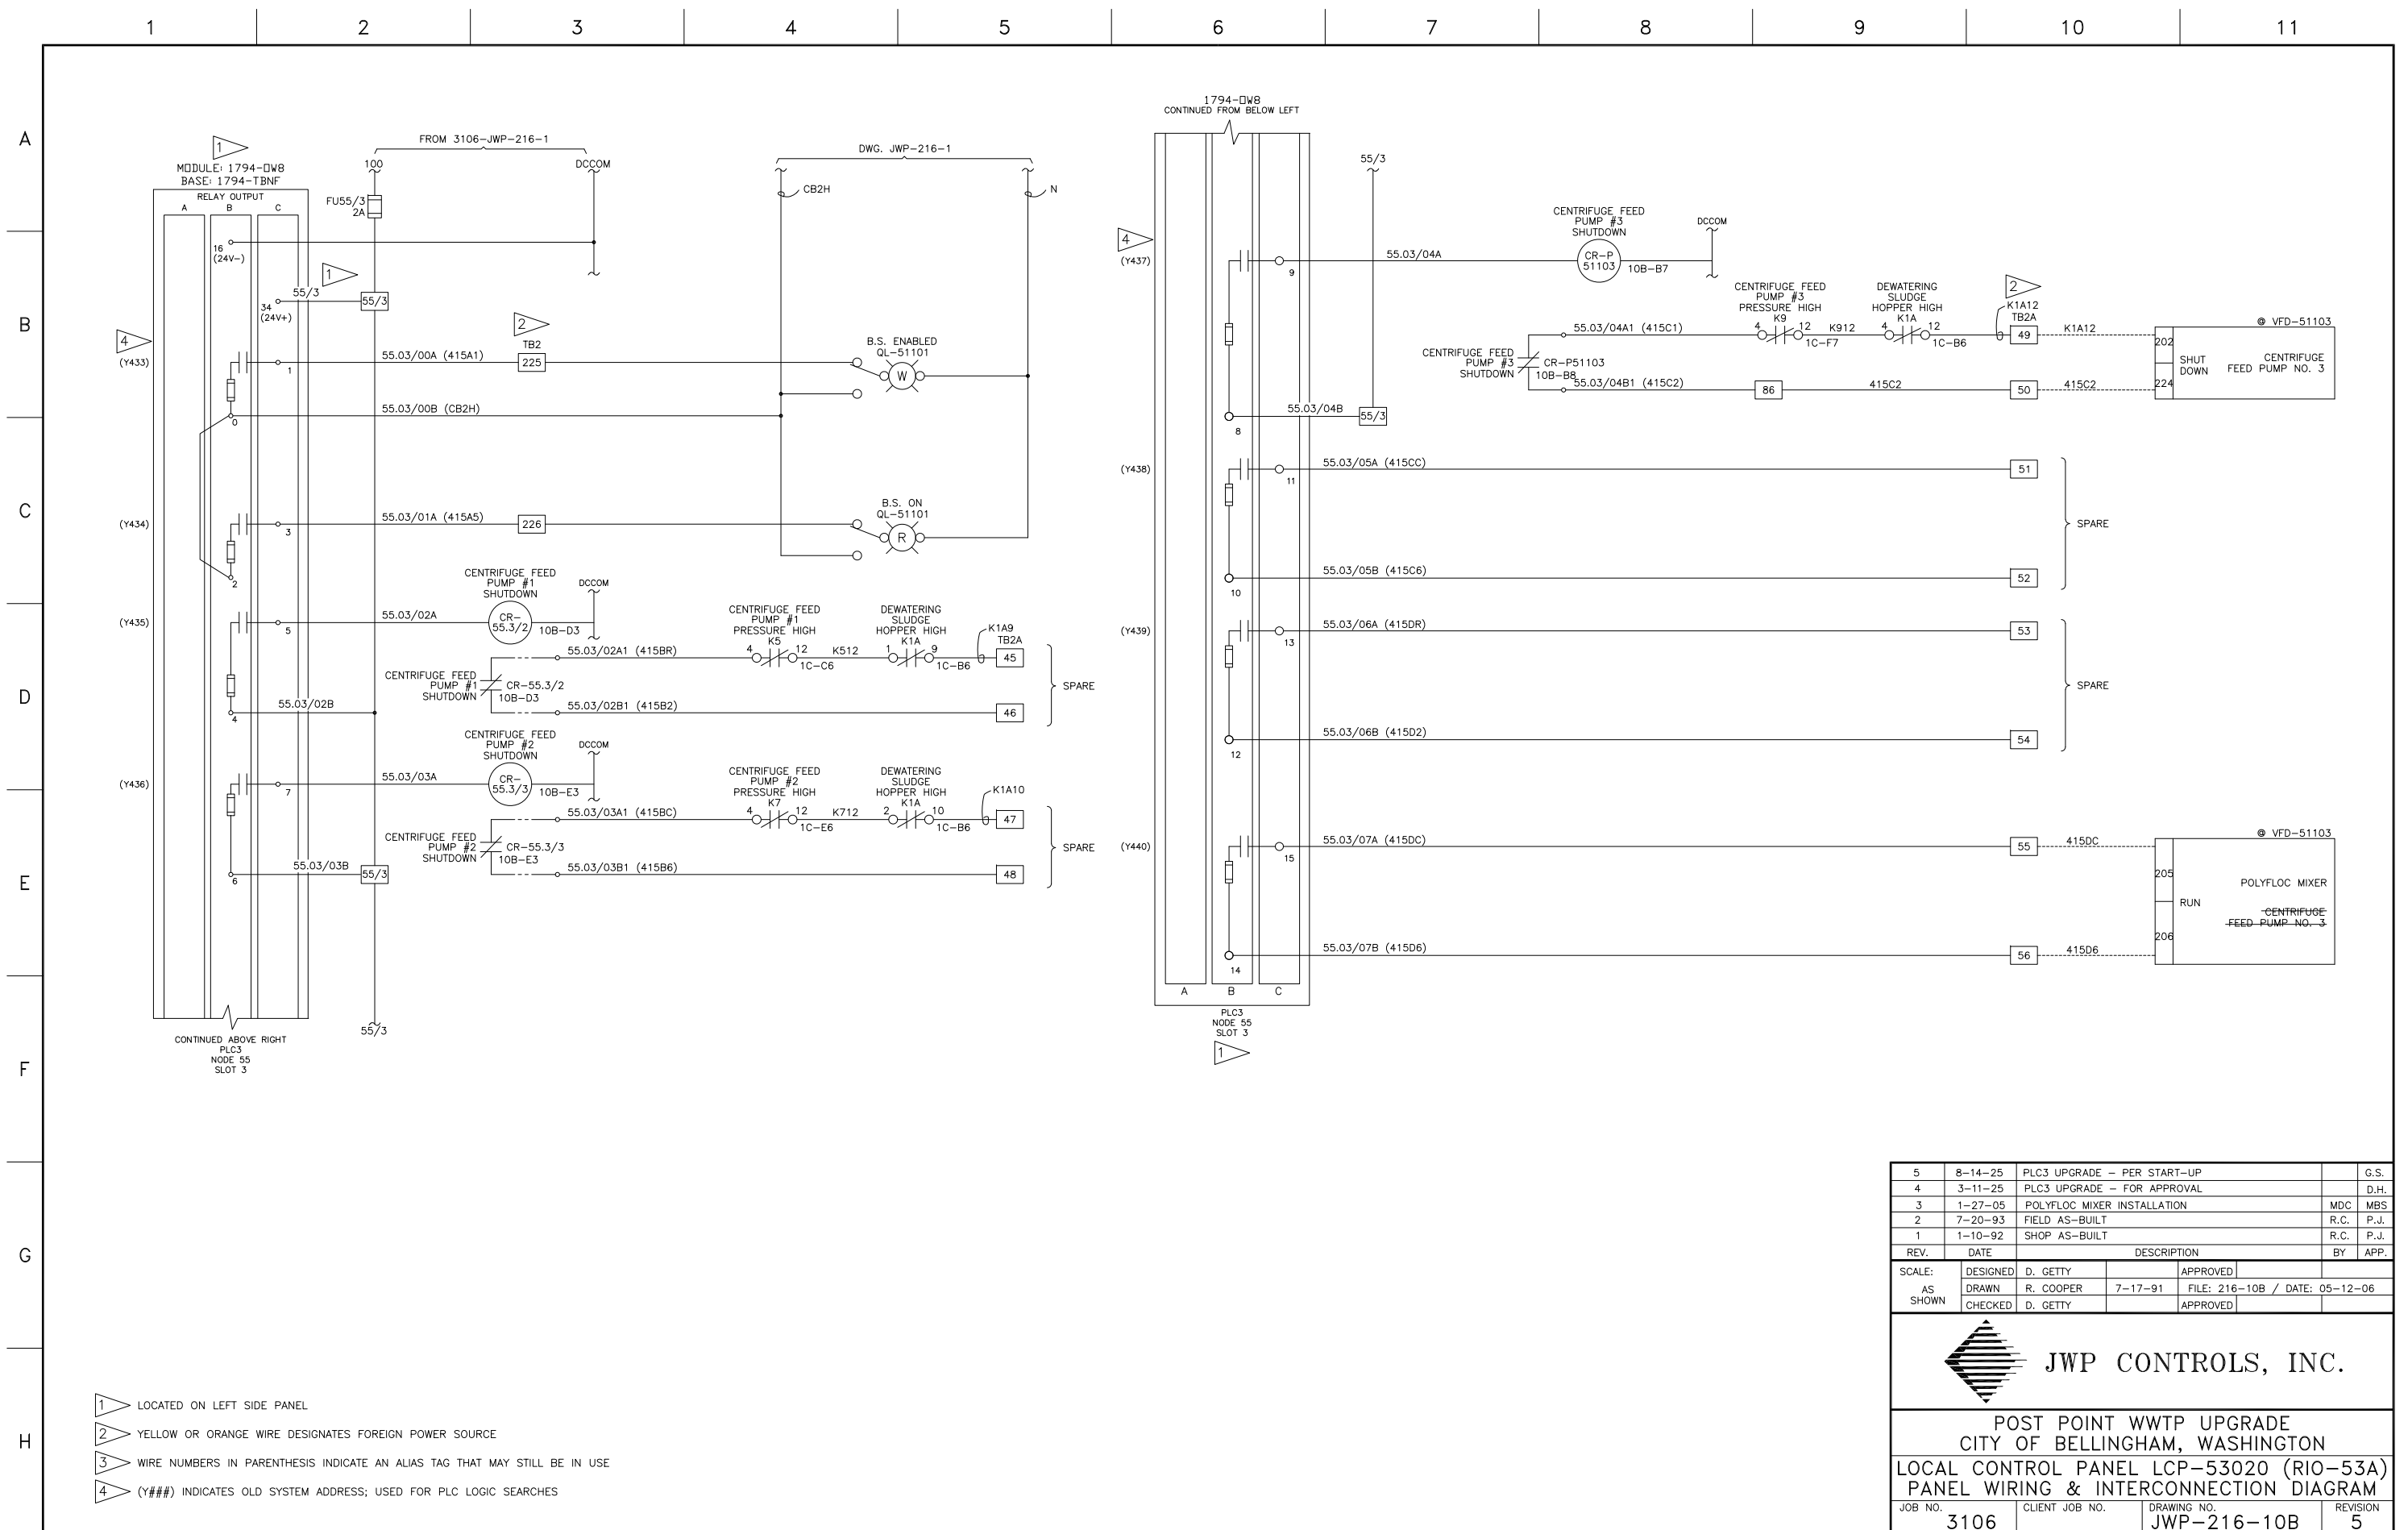

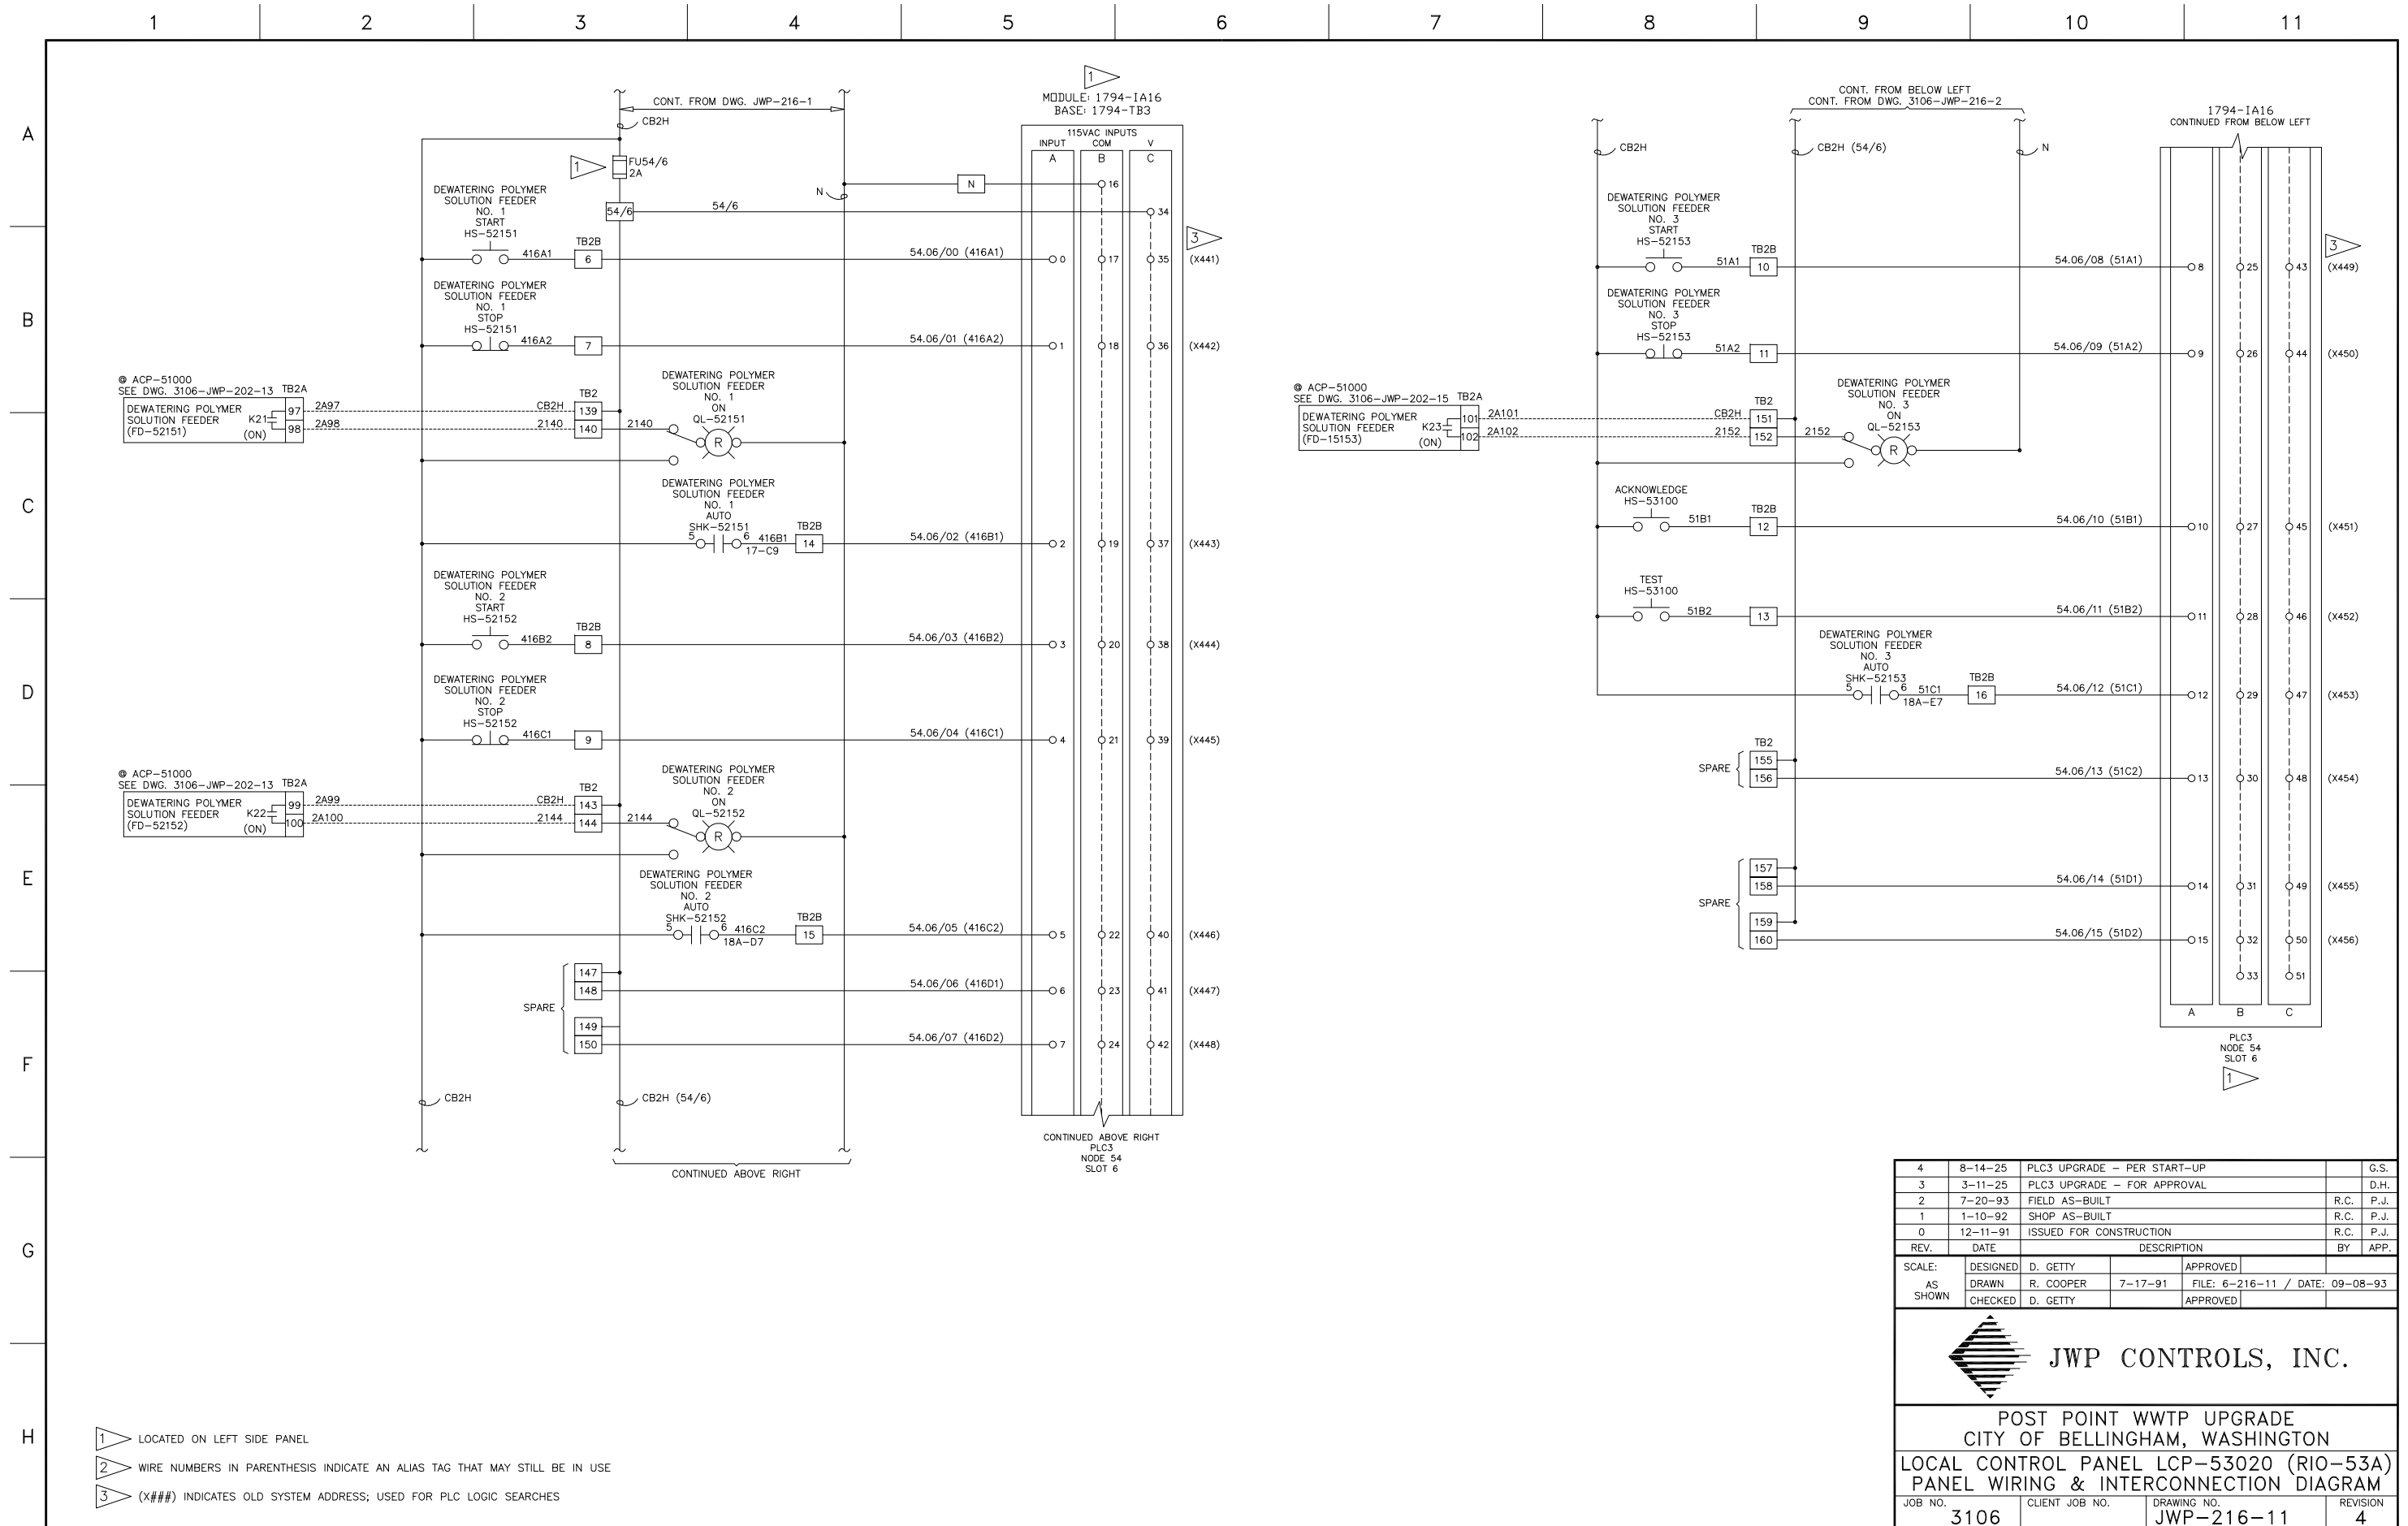

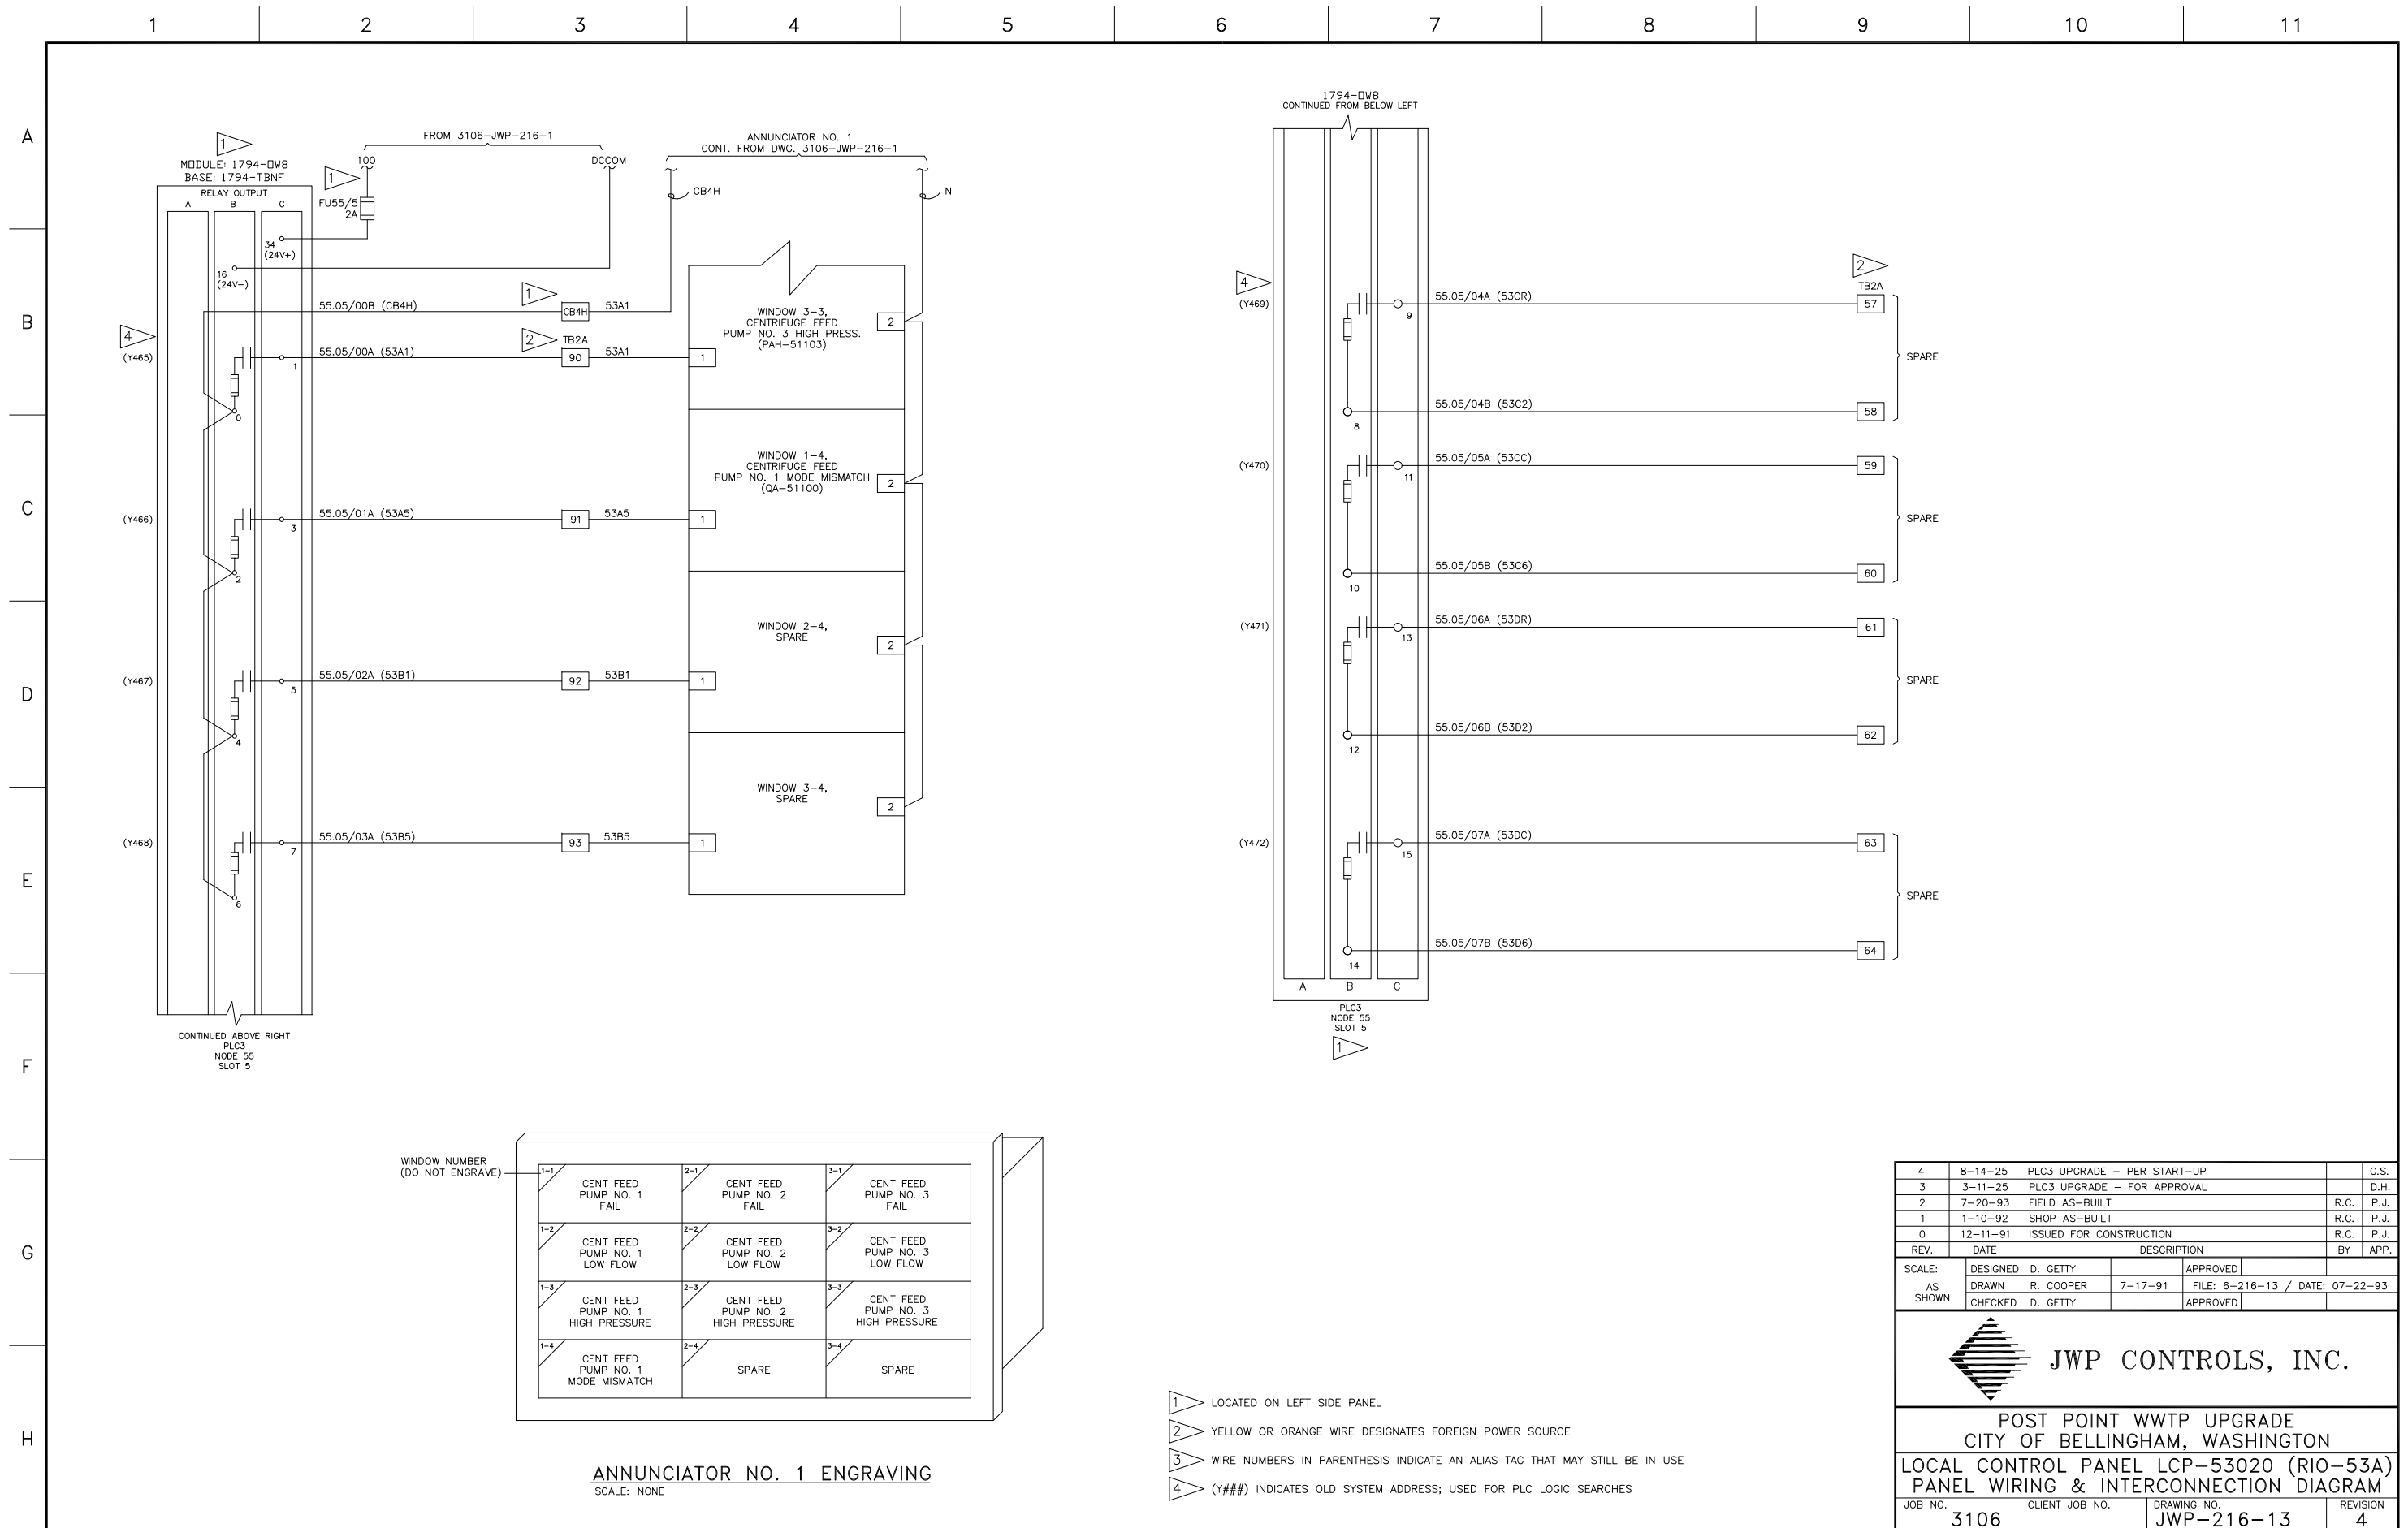

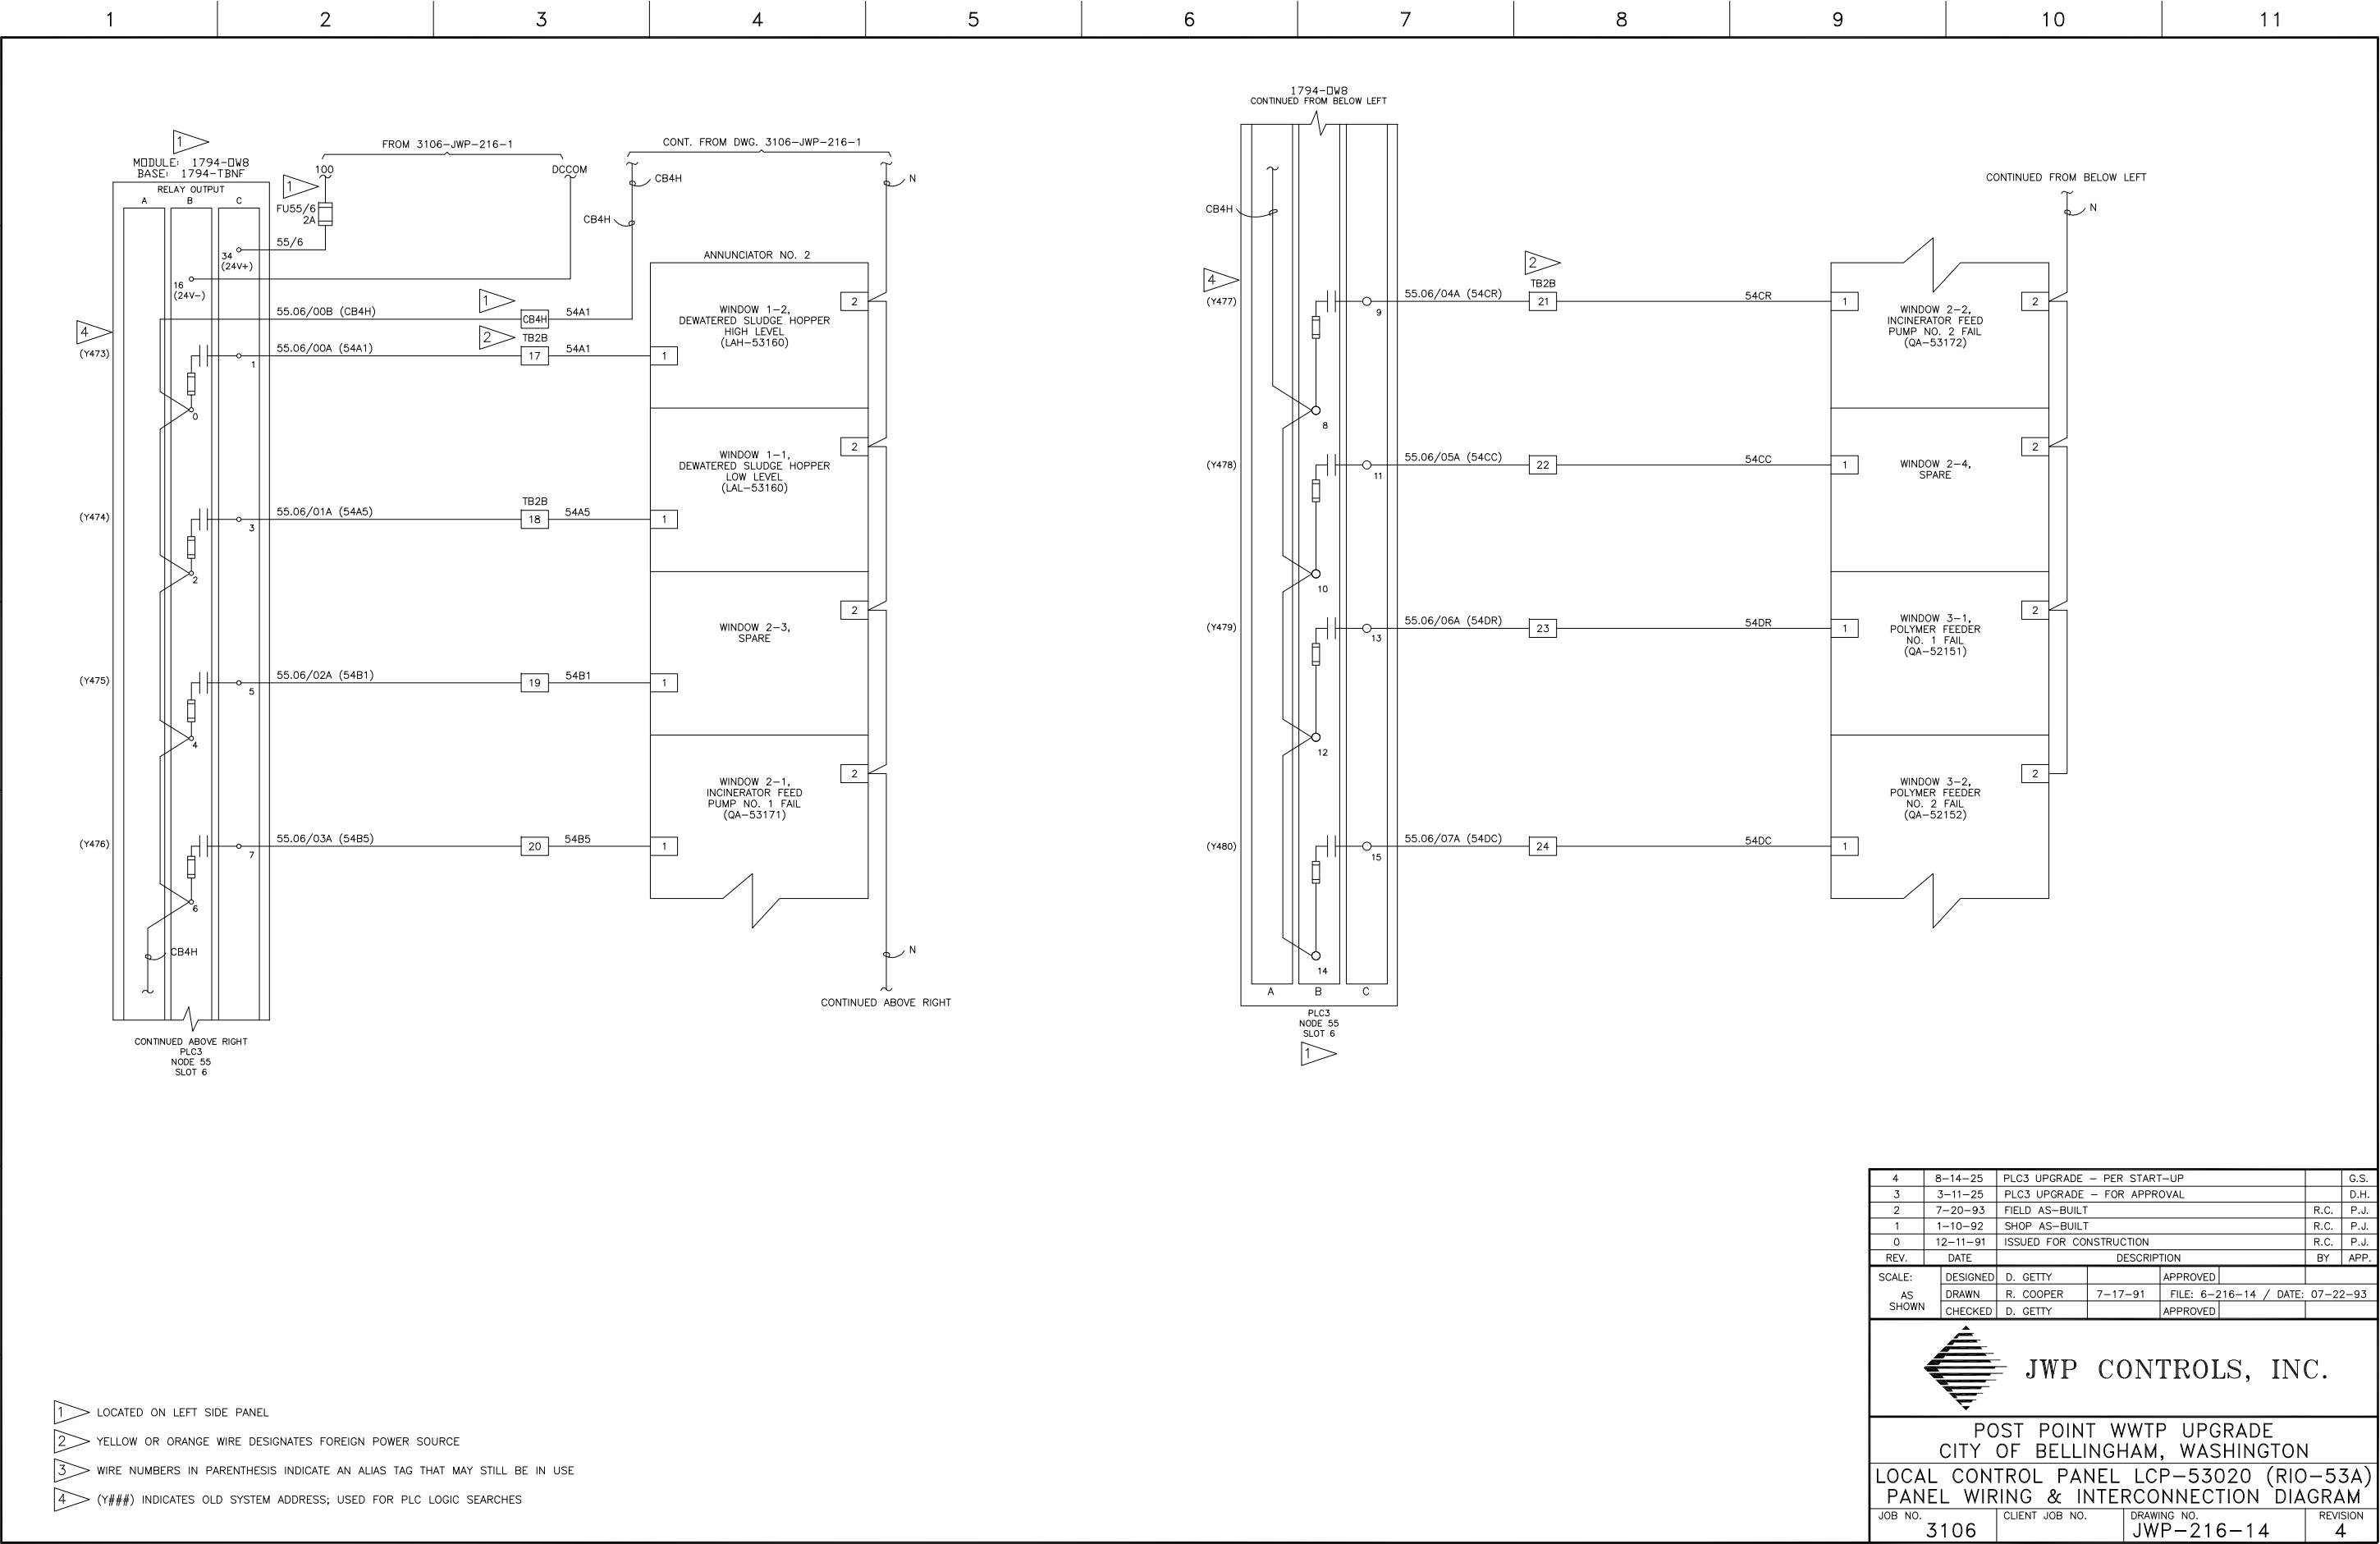

4	8-14-25	PLC3 UPGRADE - PER START-UP		G.S.
3	3-11-25	PLC3 UPGRADE - FOR APPROVAL		D.H.
2	7-20-93	FIELD AS-BUILT		R.C. P.J.
1	1-10-92	SHOP AS-BUILT		R.C. P.J.
0	12-11-91	ISSUED FOR CONSTRUCTION		R.C. P.J.
REV.	DATE	DESCRIPTION		BY APP.
SCALE:	DESIGNED	D. GETTY	APPROVED	
AS	DRAWN	R. COOPER	7-17-91	FILE: 6-216-14 / DATE: 07-22-93
SHOWN	CHECKED	D. GETTY	APPROVED	





JWP CONTROLS, INC.


POST POINT WWTP UPGRADE
CITY OF BELLINGHAM, WASHINGTON


LOCAL CONTROL PANEL LCP-53020 (RIO-53A)
PANEL WIRING & INTERCONNECTION DIAGRAM


JOB NO.	CLIENT JOB NO.	DRAWING NO.	REVISION
3106		JWP-216-14	4

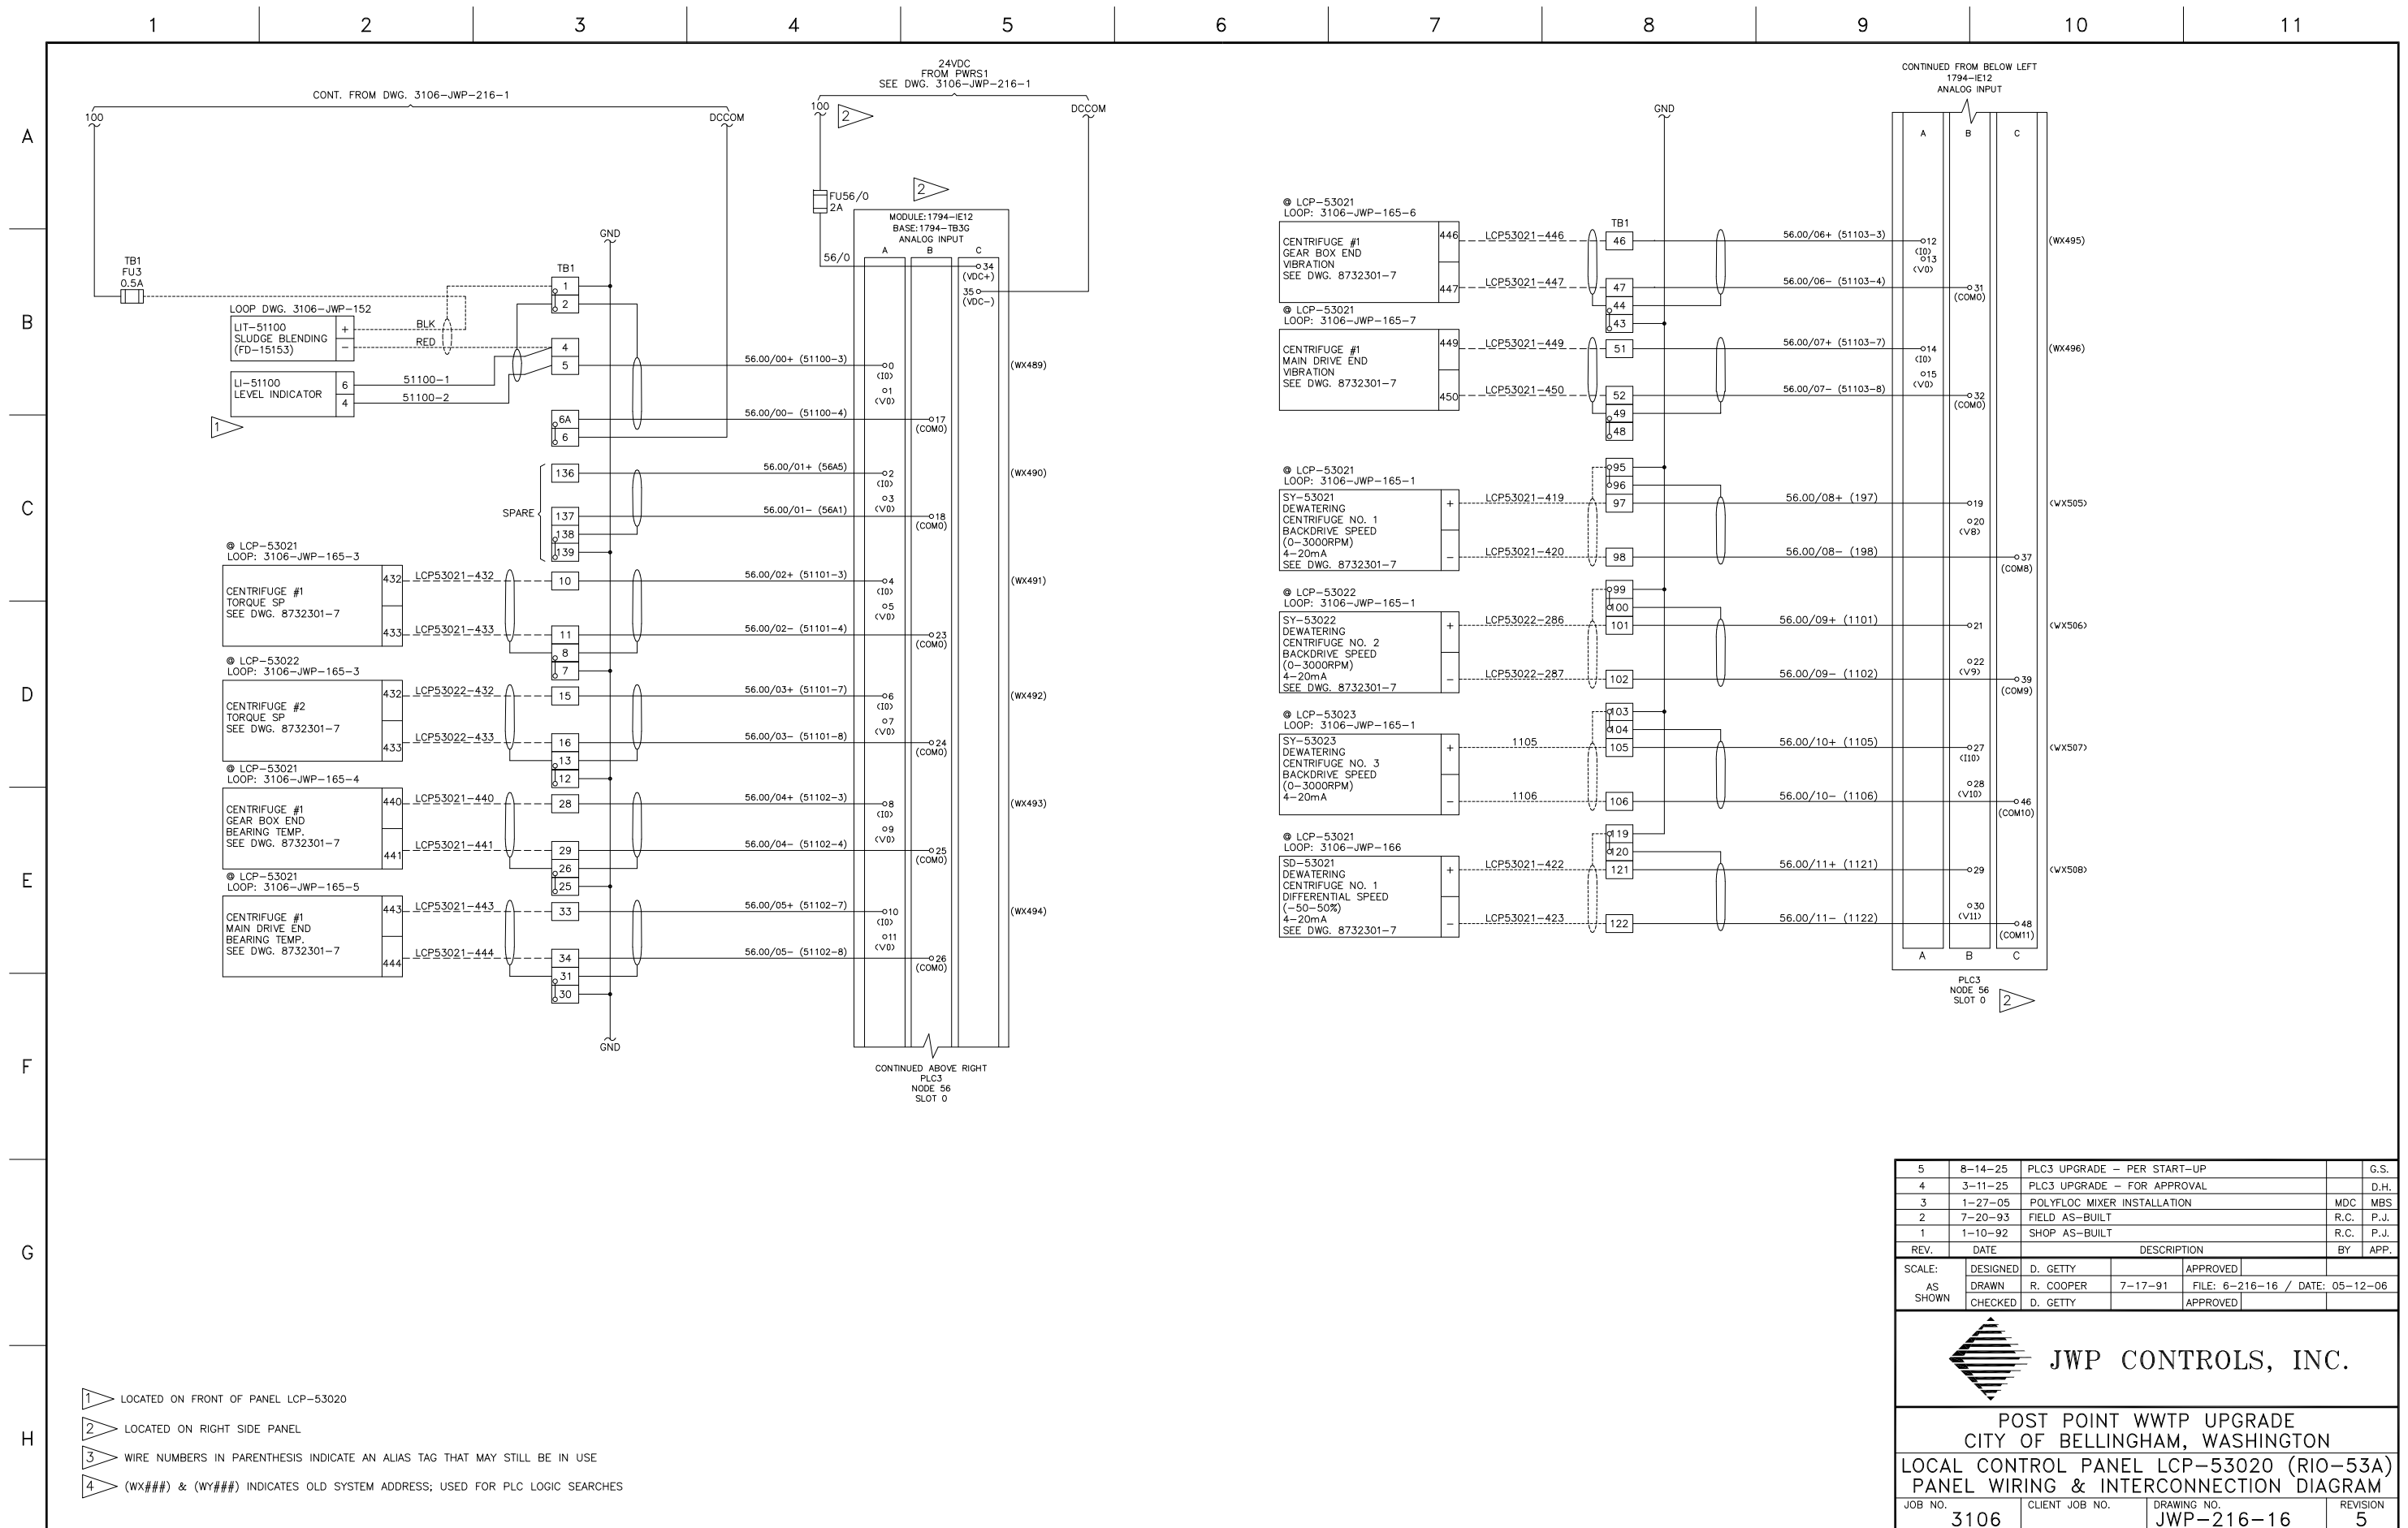

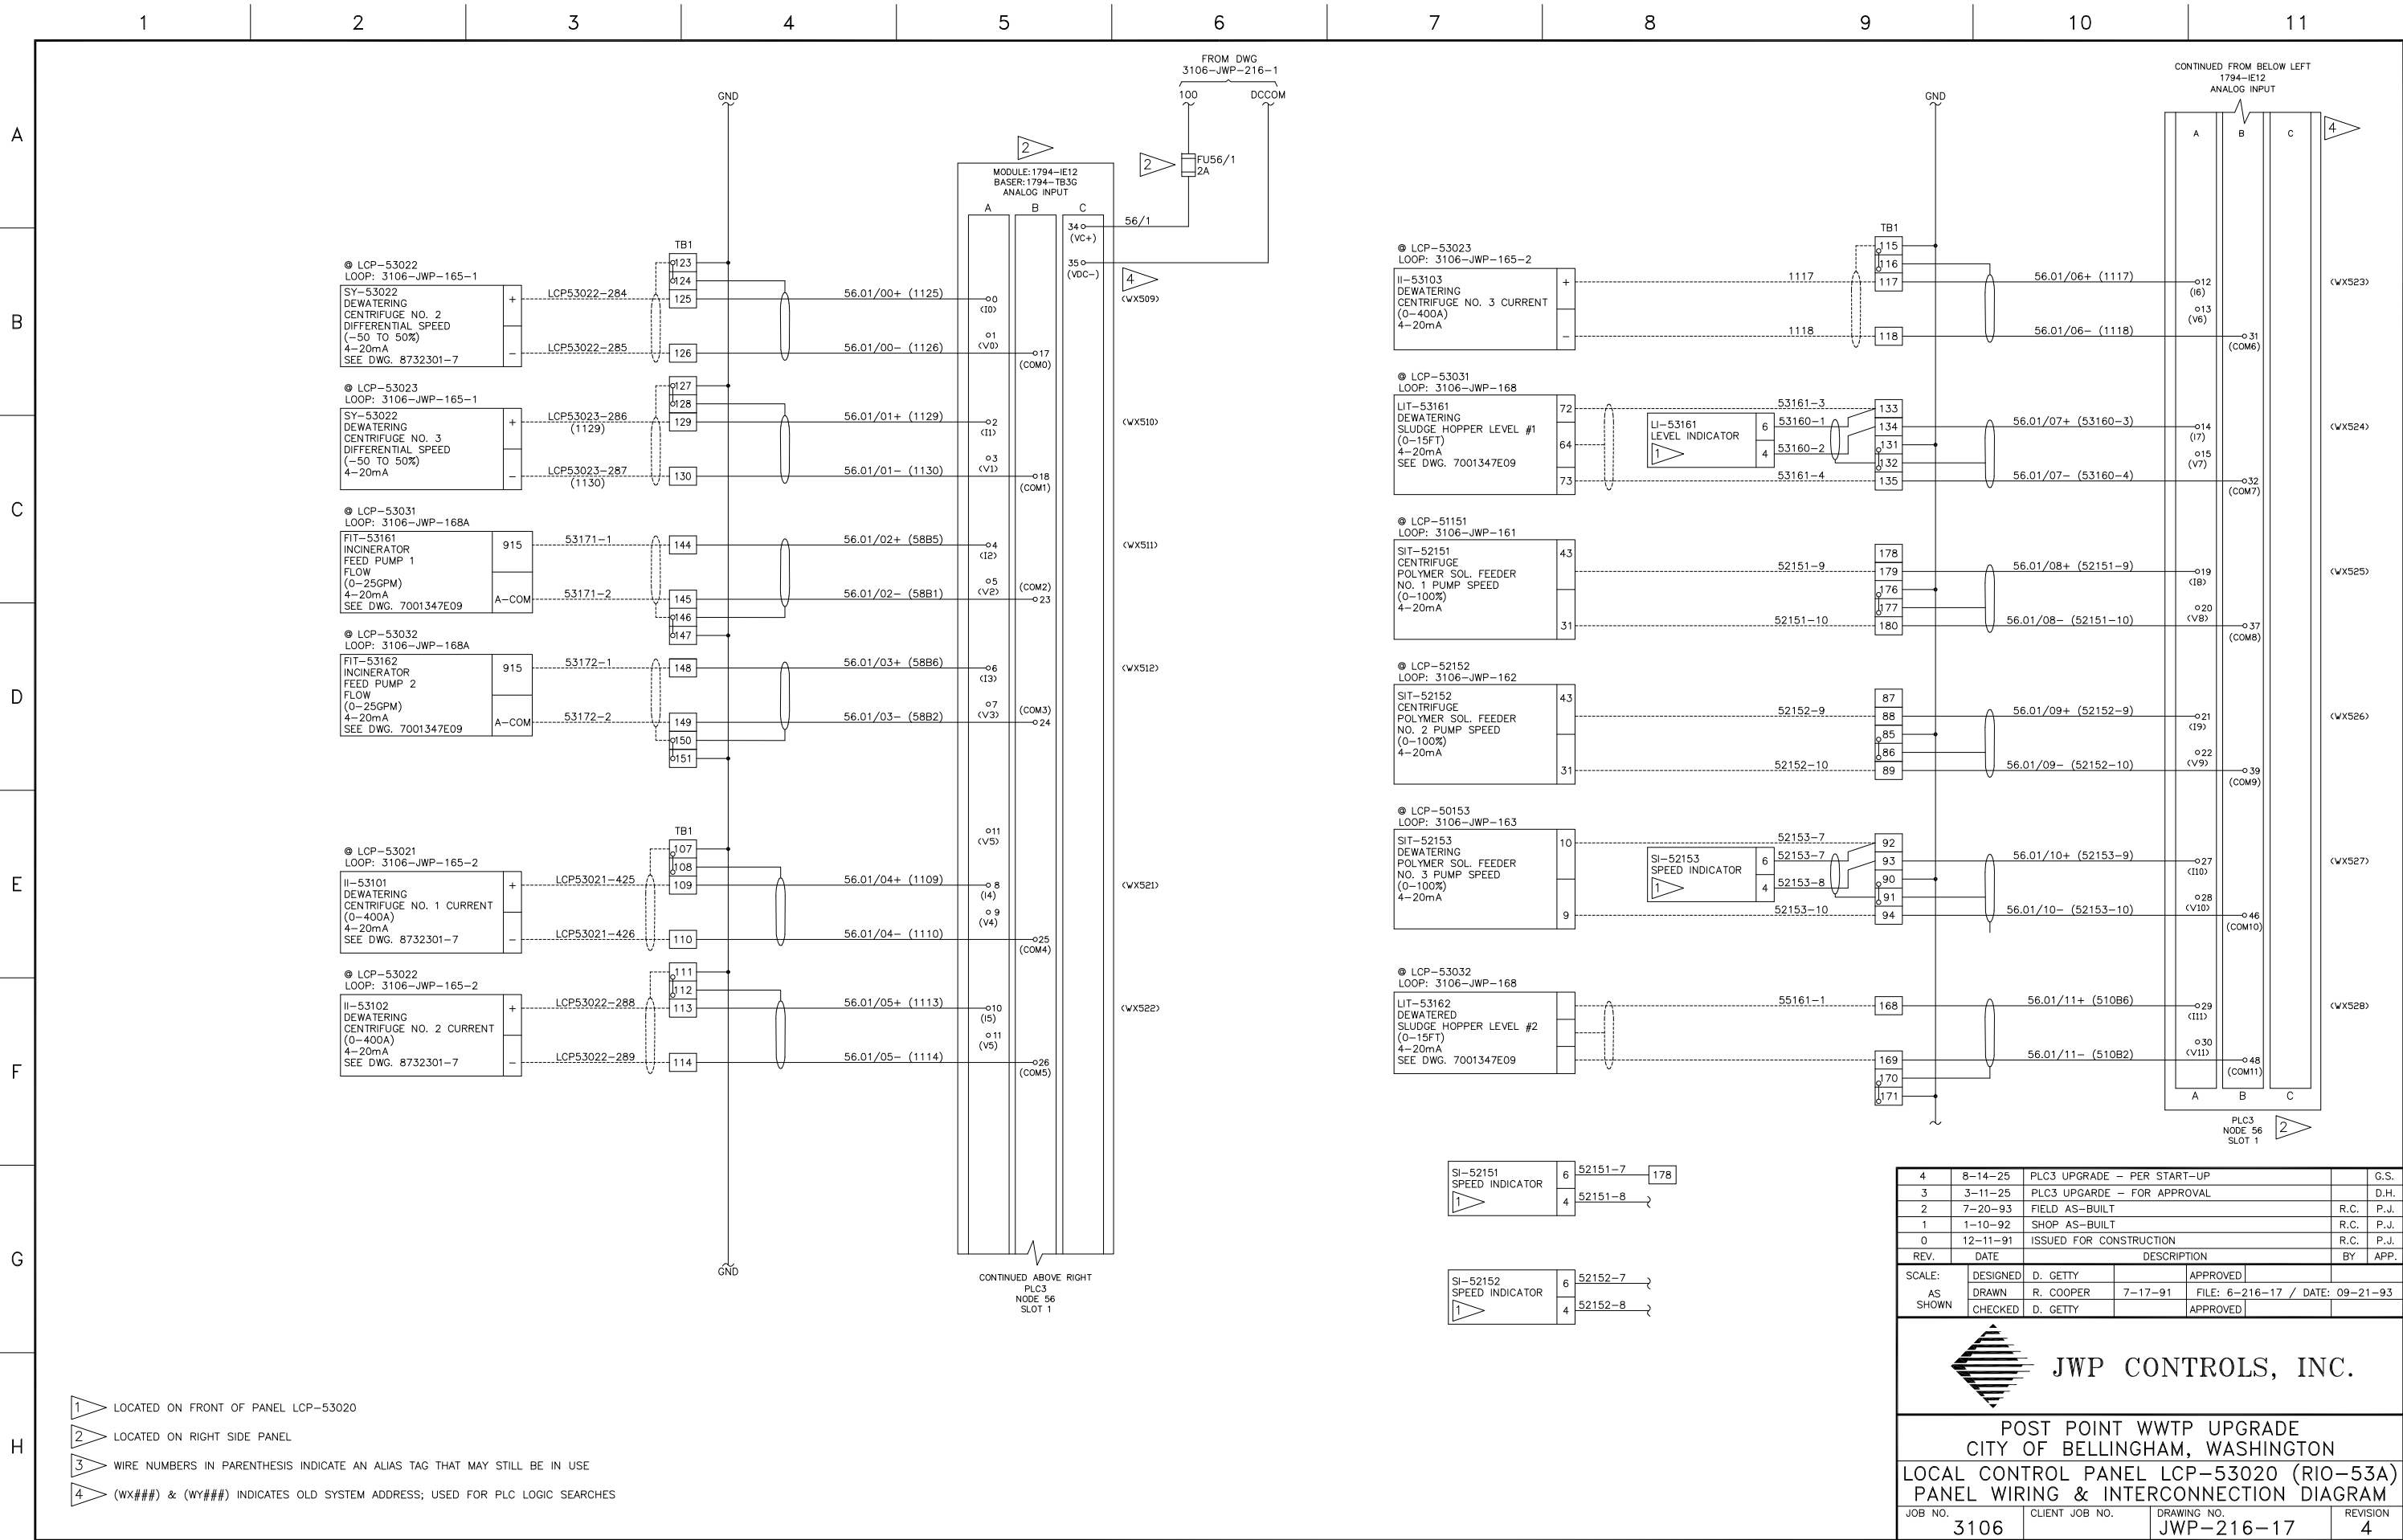

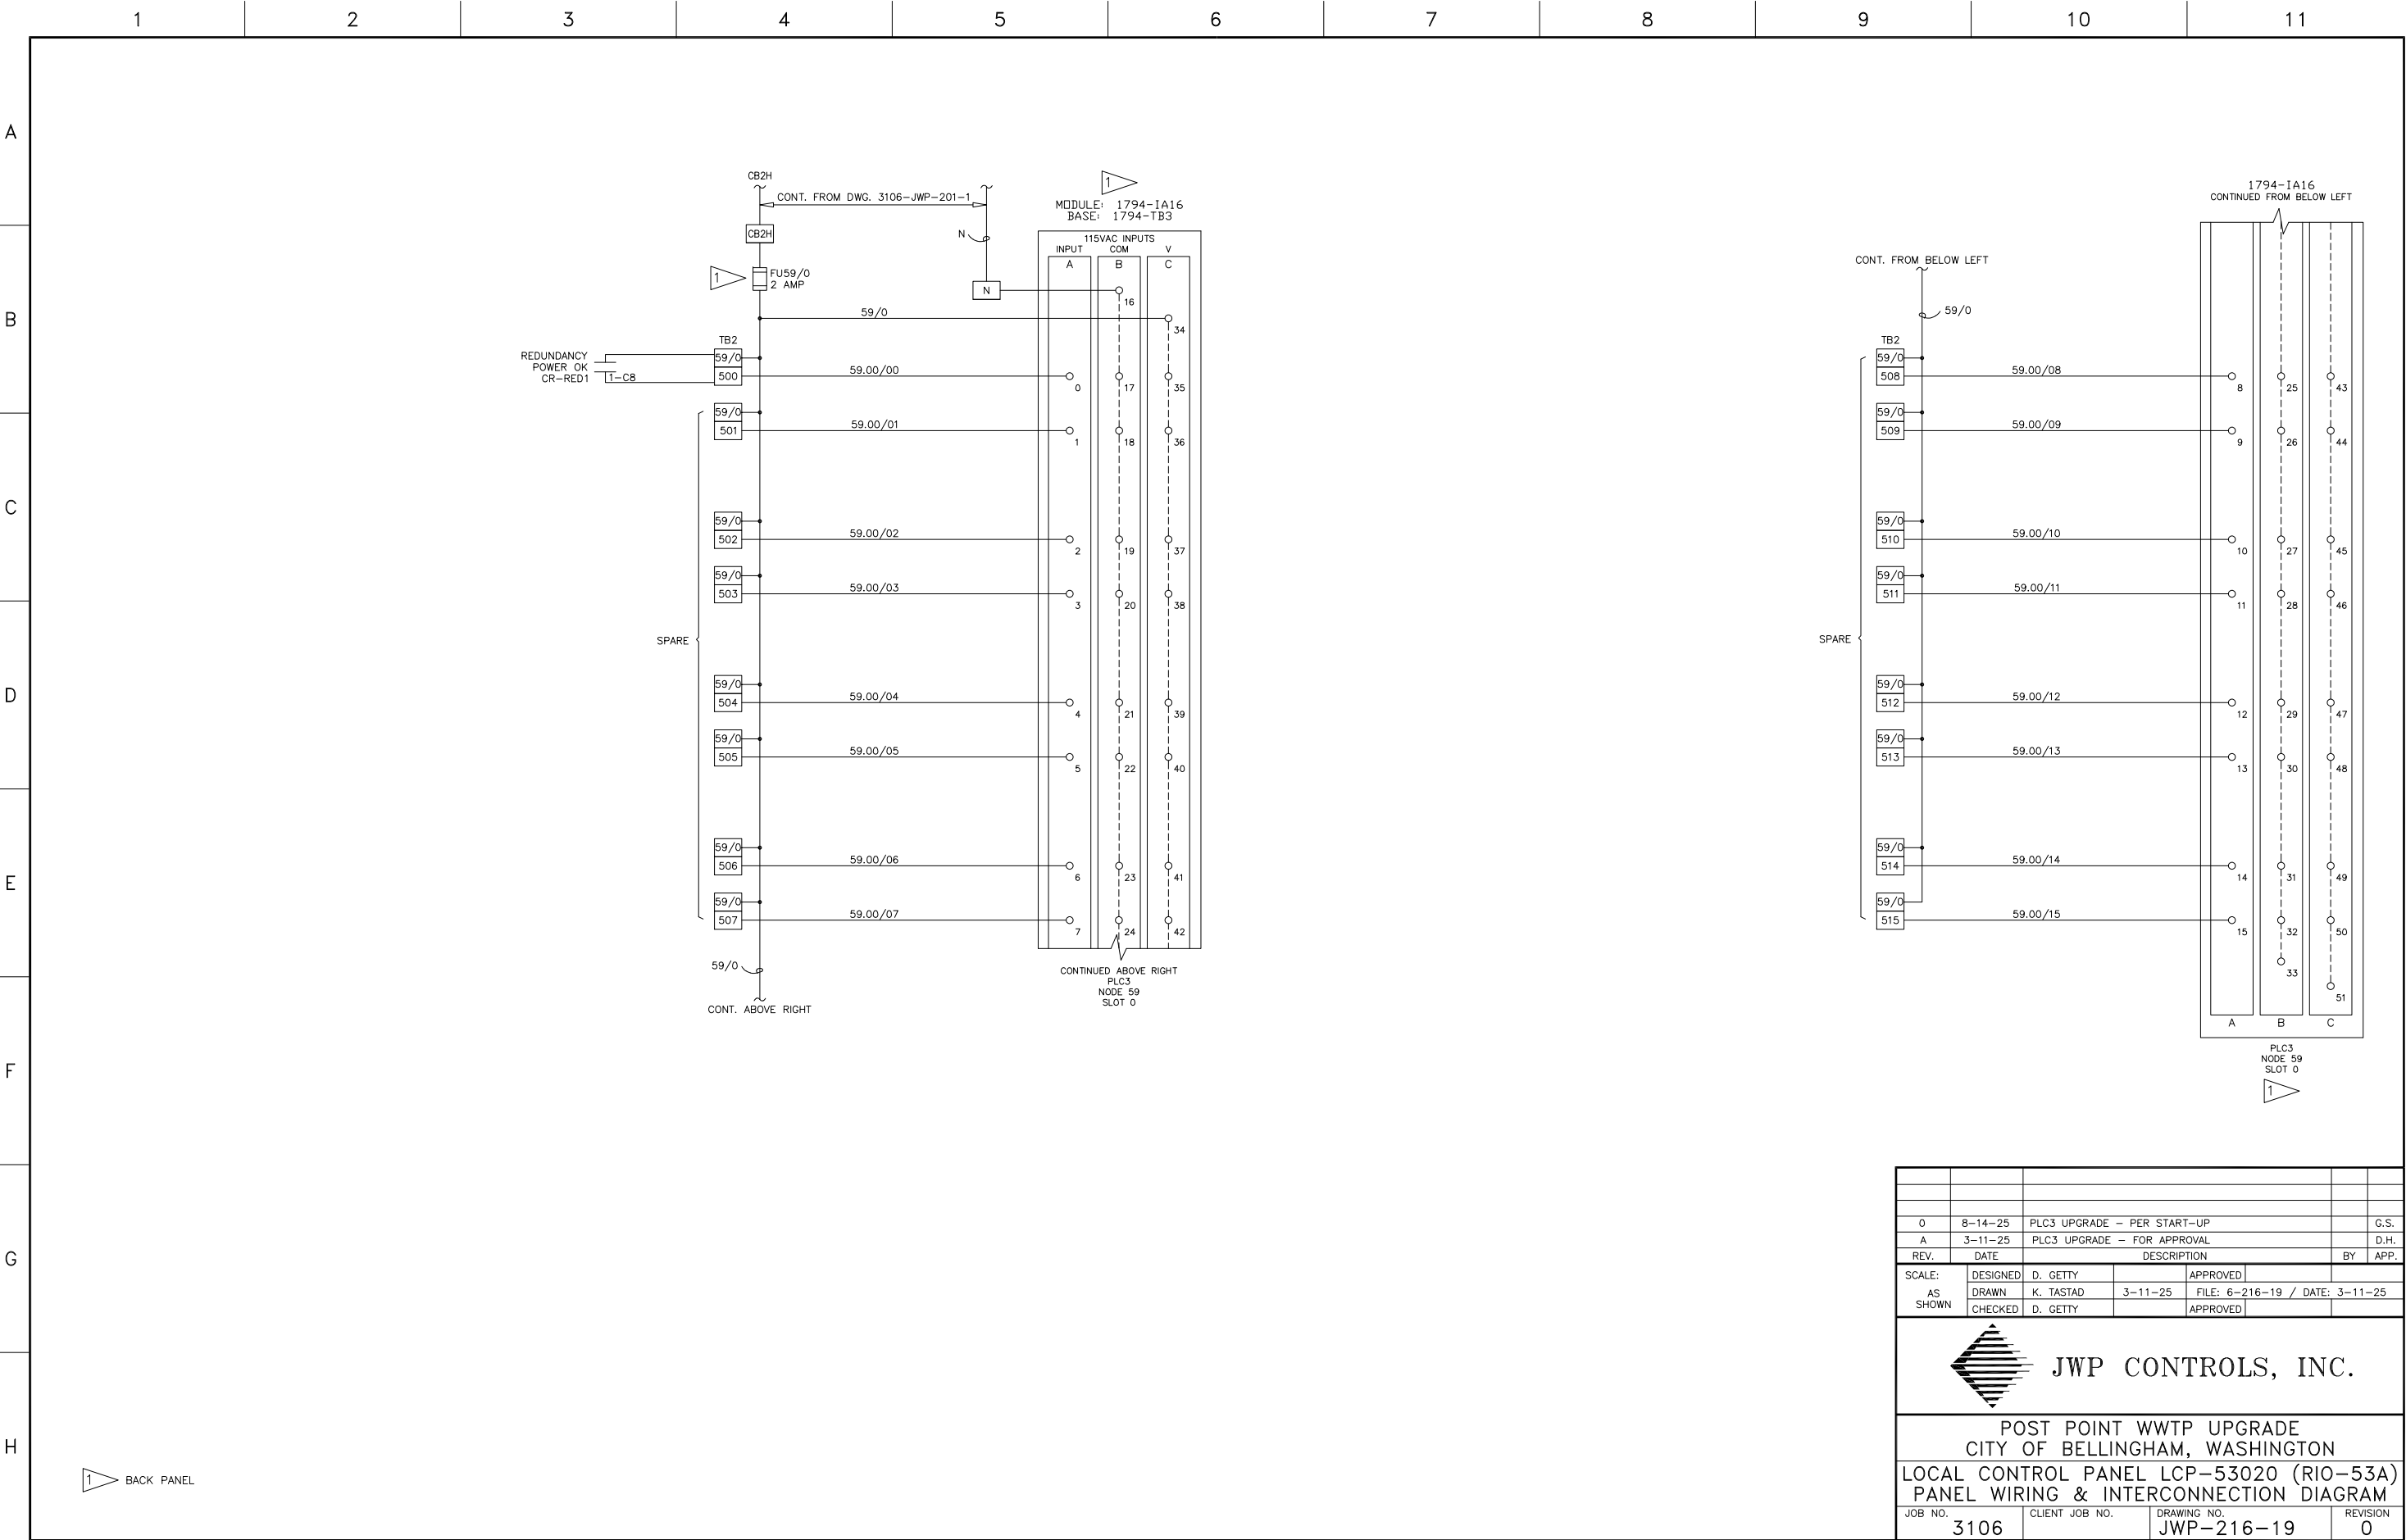

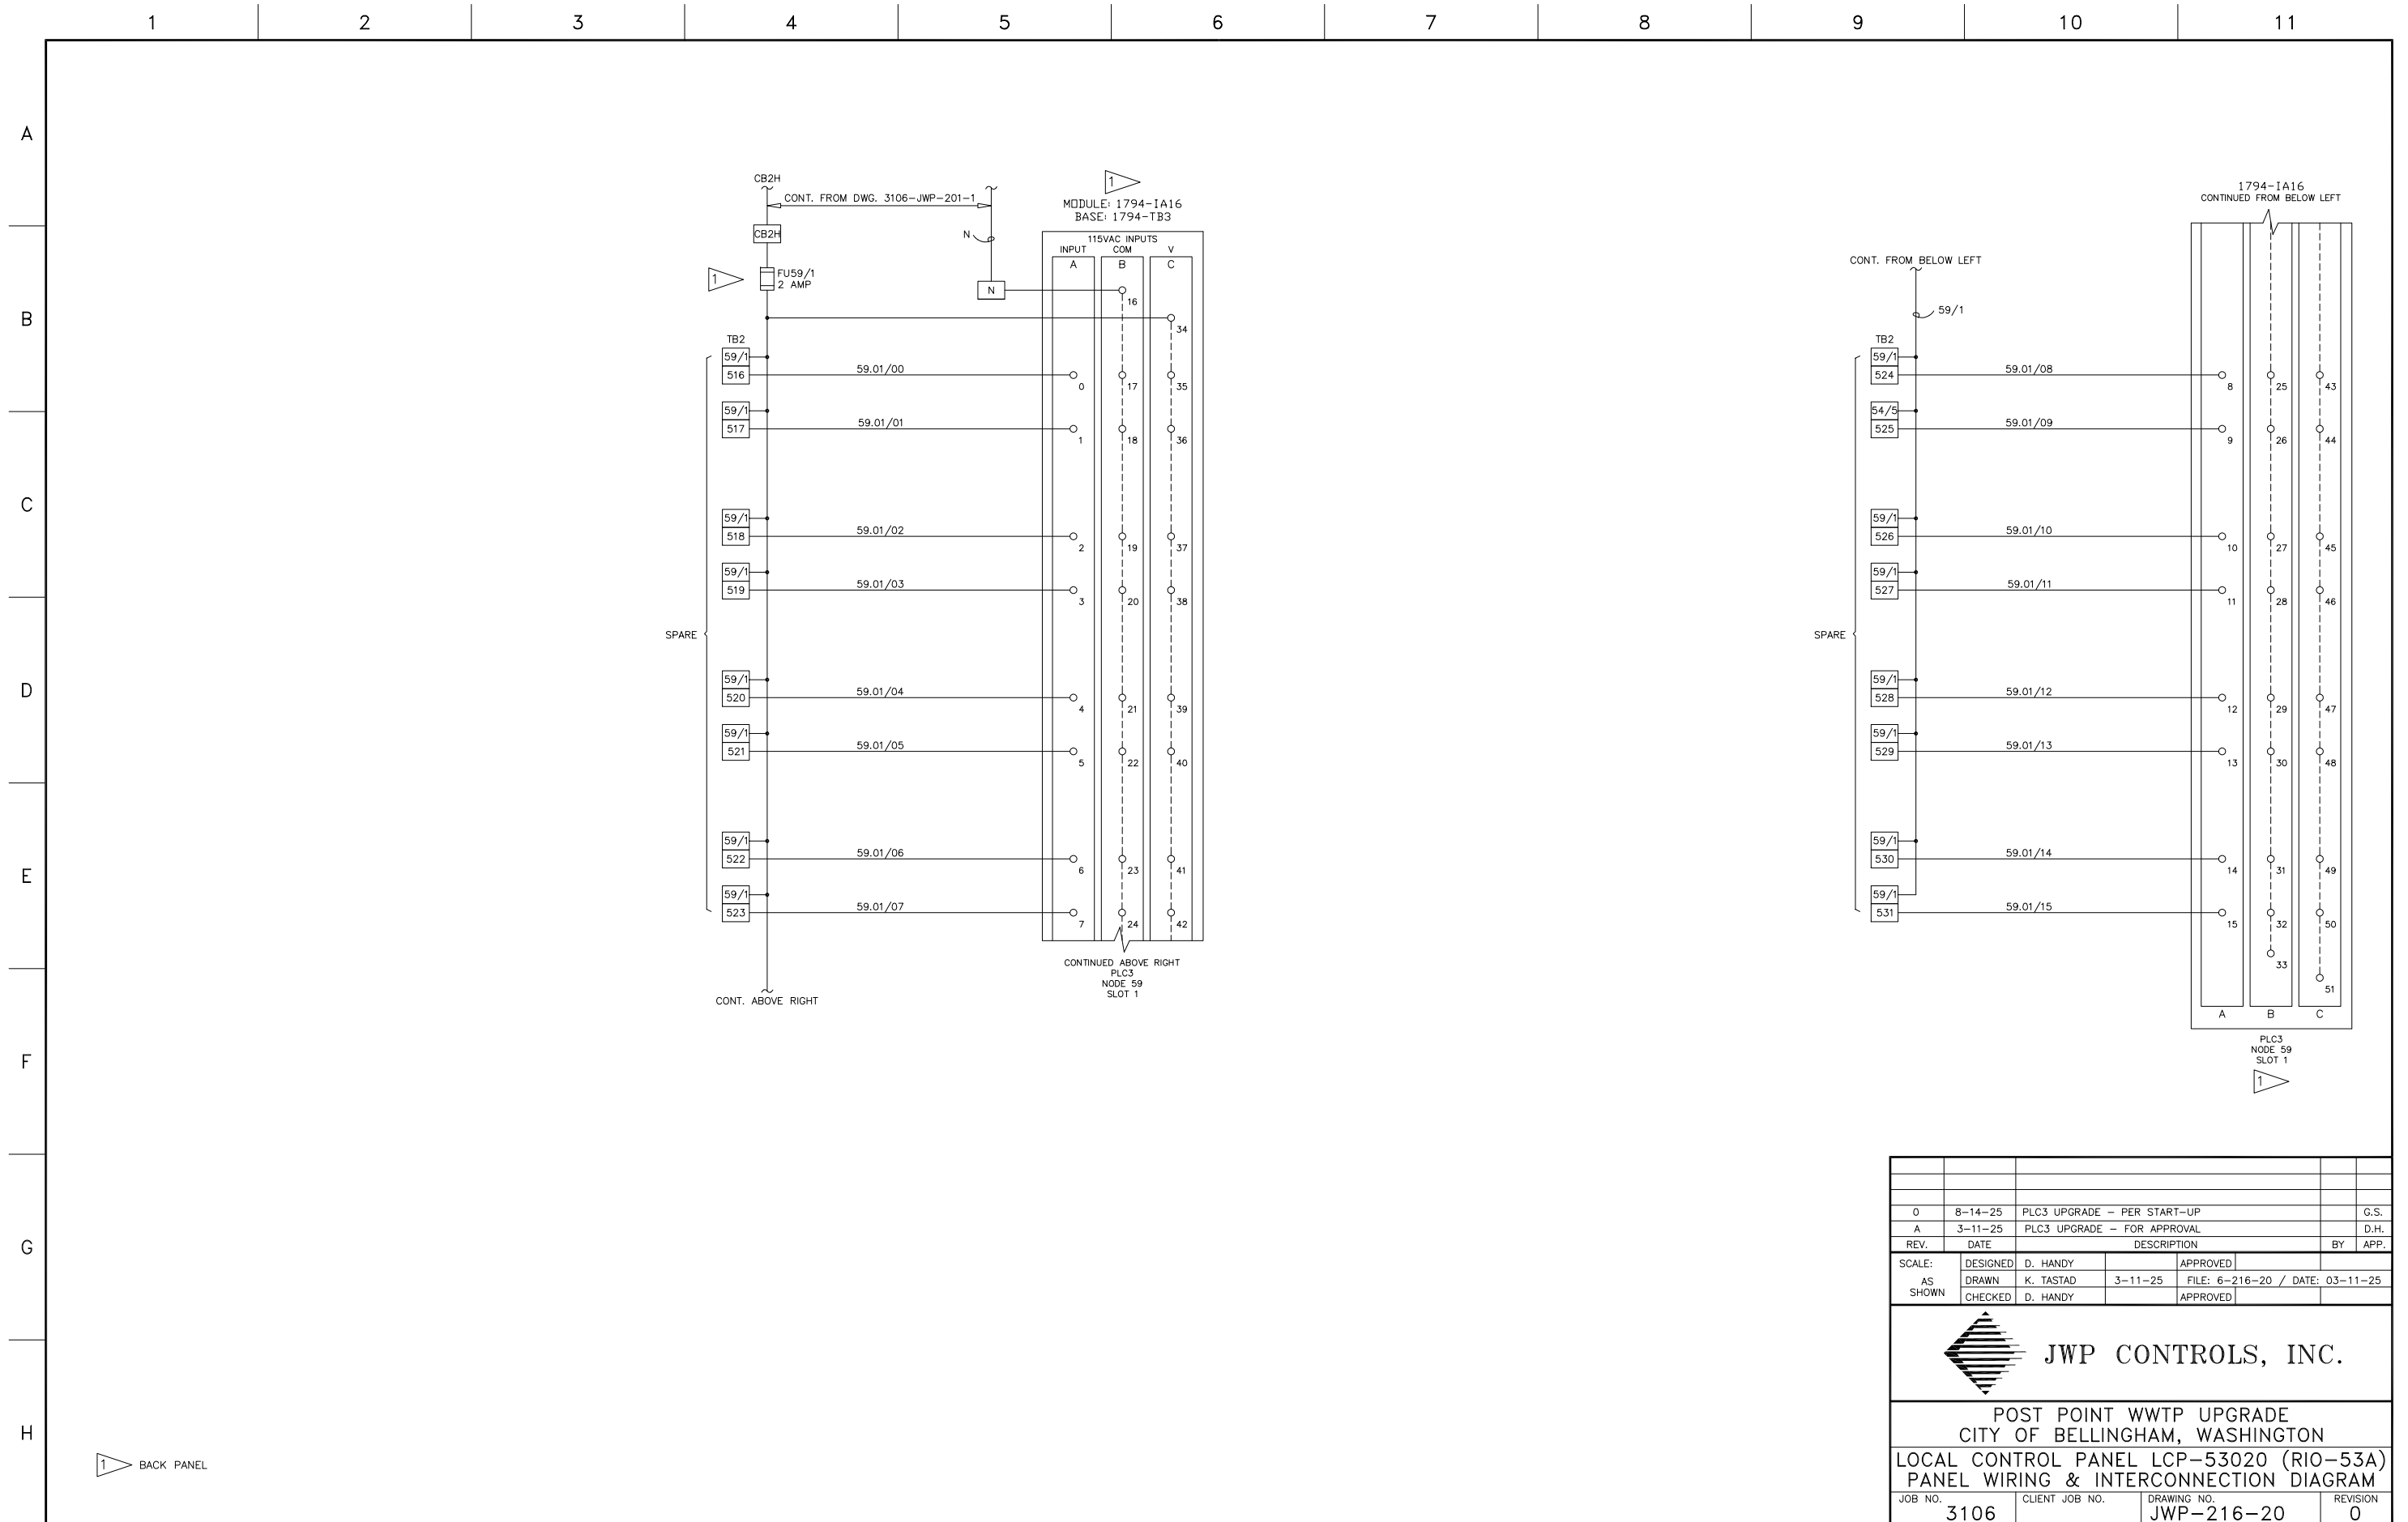

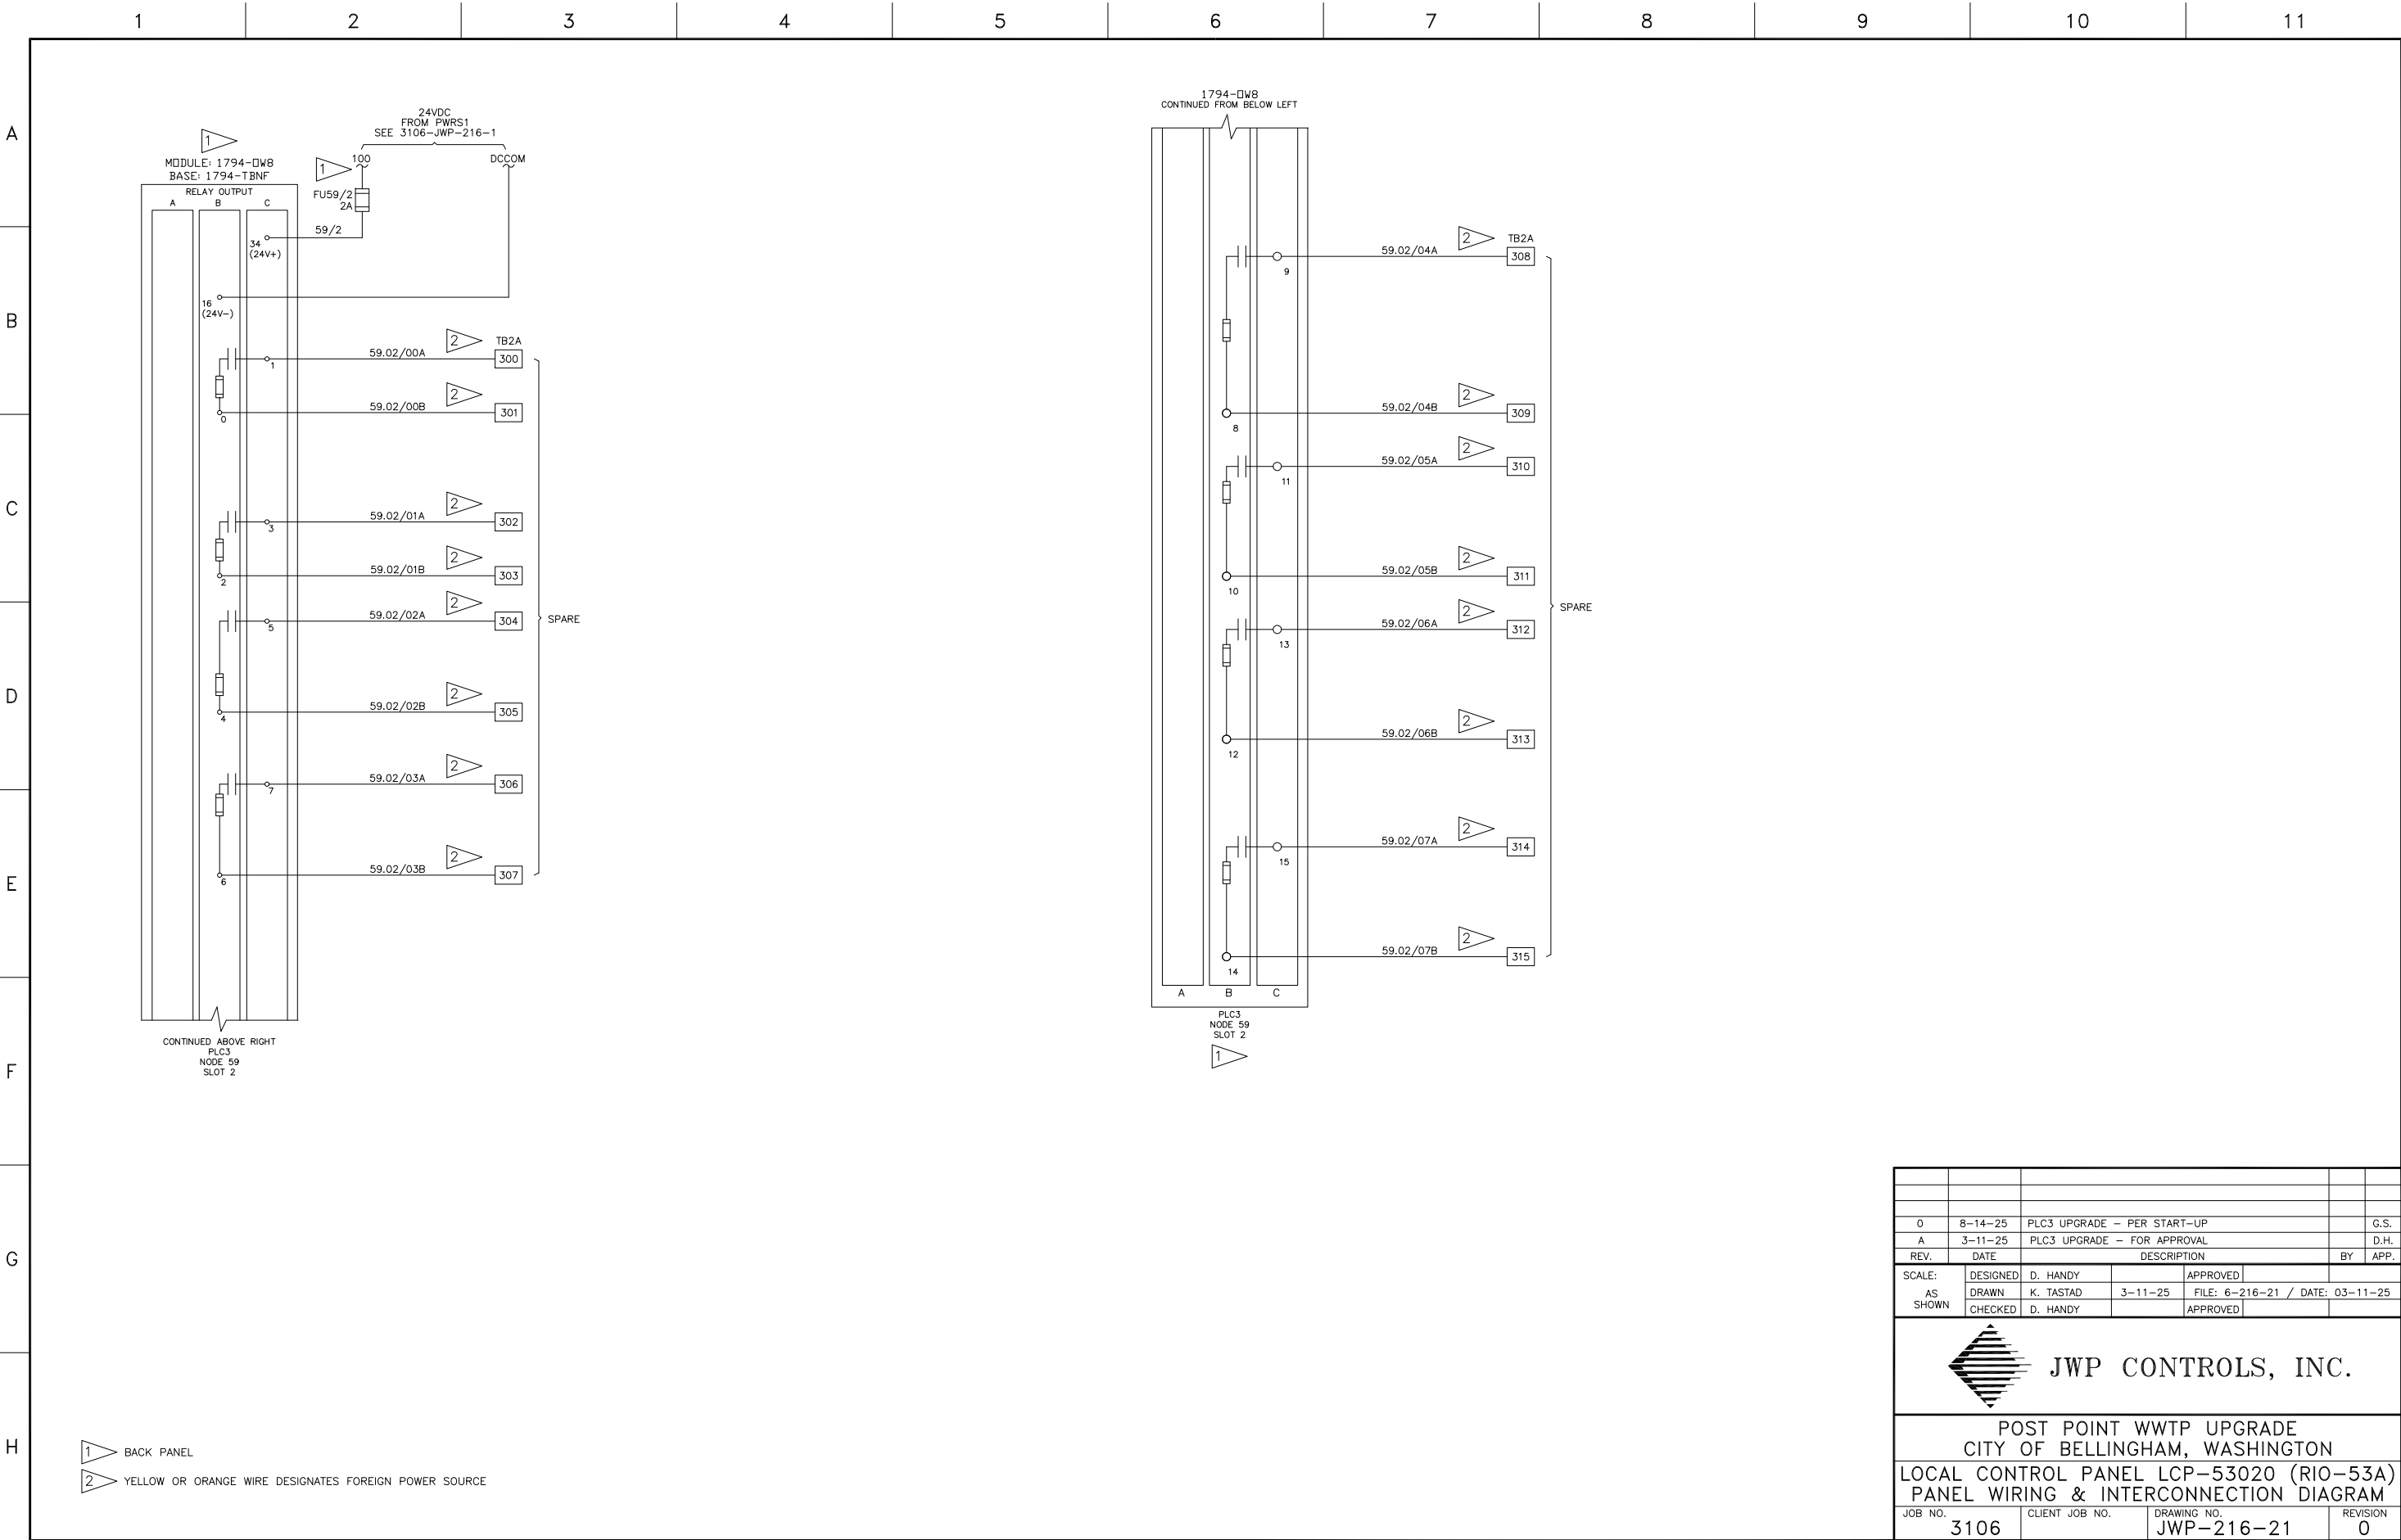


1

BACK PANEL



2

YELLOW OR ORANGE WIRE DESIGNATES FOREIGN POWER SOURCE


0	8-14-25	PLC3 UPGRADE - PER START-UP			G.S.
A	3-11-25	PLC3 UPGRADE - FOR APPROVAL			D.H.
REV.	DATE	DESCRIPTION			BY APP.
SCALE:	DESIGNED	D. HANDY		APPROVED	
AS SHOWN	DRAWN	K. TASTAD	3-11-25	FILE: 6-216-21 / DATE: 03-11-25	
	CHECKED	D. HANDY		APPROVED	
JWP CONTROLS, INC.					
POST POINT WWTP UPGRADE CITY OF BELLINGHAM, WASHINGTON					
LOCAL CONTROL PANEL LCP-53020 (RIO-53A) PANEL WIRING & INTERCONNECTION DIAGRAM					
JOB NO.	3106	CLIENT JOB NO.	DRAWING NO.	REVISION	
			JWP-216-21	0	

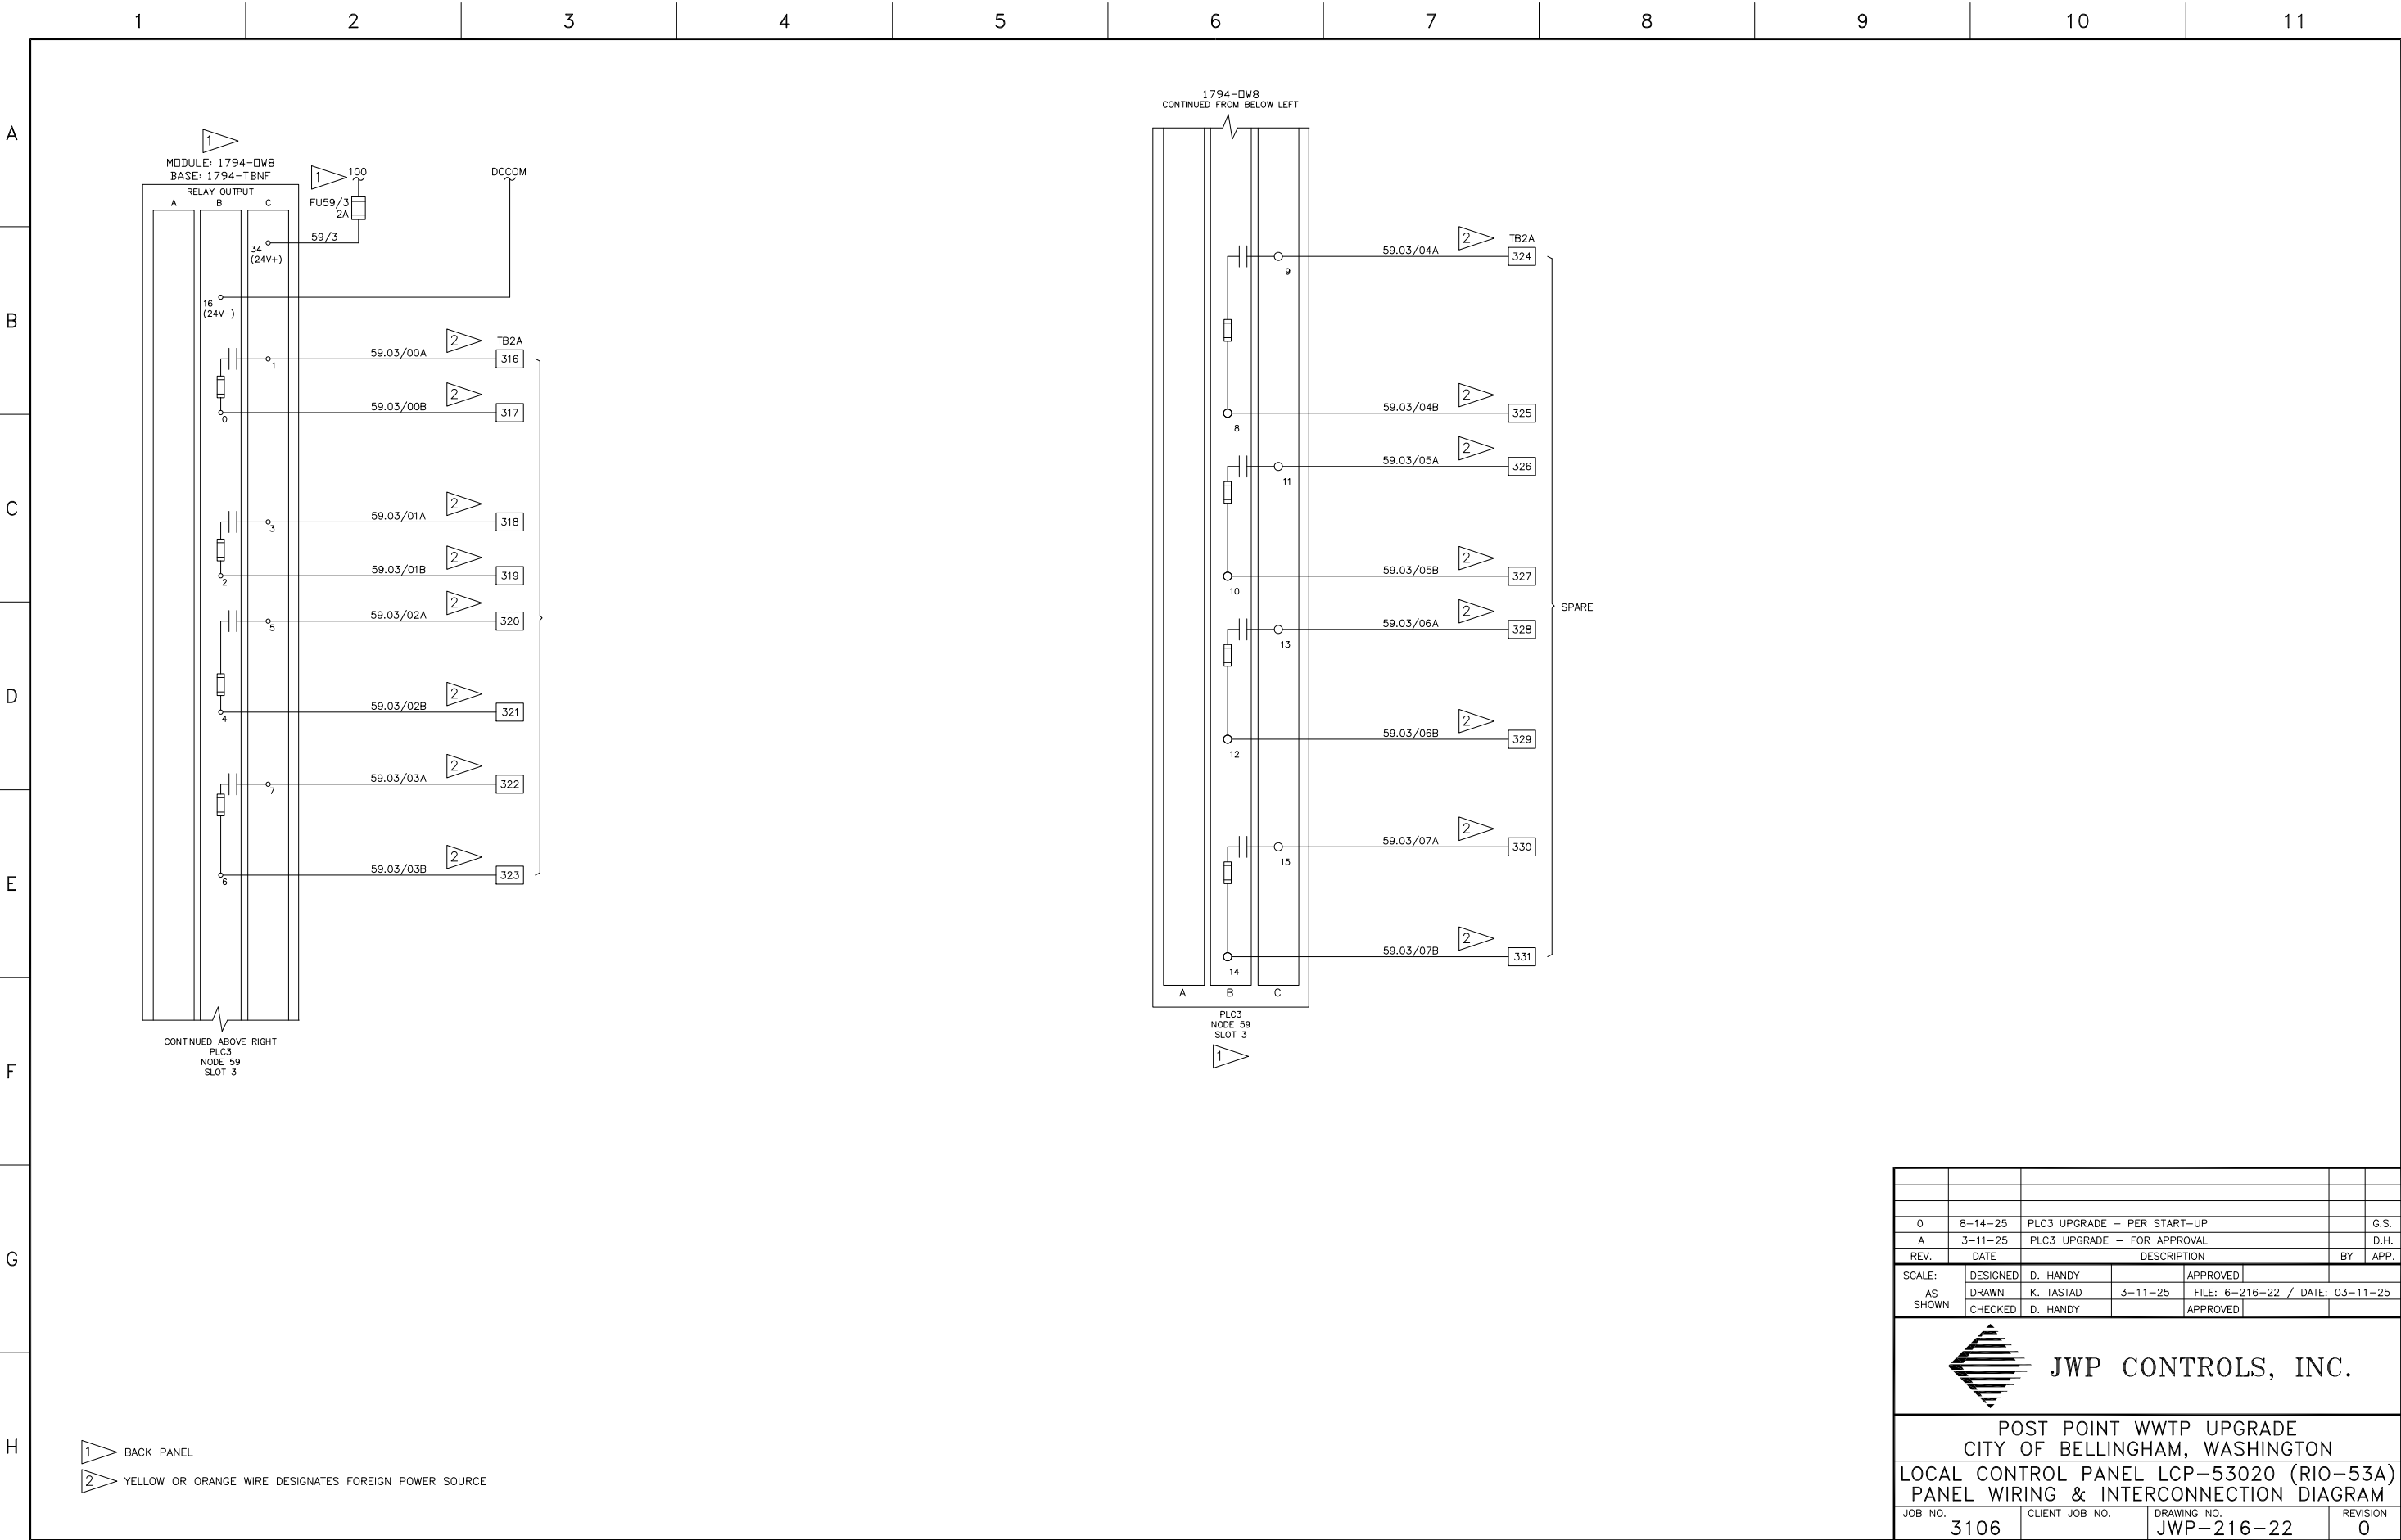


0	8-14-25	PLC3 UPGRADE - PER START-UP			G.S.
A	3-11-25	PLC3 UPGRADE - FOR APPROVAL			D.H.
REV.	DATE	DESCRIPTION			BY APP.
SCALE:	DESIGNED	D. HANDY		APPROVED	
AS SHOWN	DRAWN	K. TASTAD	3-11-25	FILE: 6-216-22 / DATE: 03-11-25	
	CHECKED	D. HANDY		APPROVED	
 JWP CONTROLS, INC.					
POST POINT WWTP UPGRADE CITY OF BELLINGHAM, WASHINGTON					
LOCAL CONTROL PANEL LCP-53020 (RIO-53A) PANEL WIRING & INTERCONNECTION DIAGRAM					
JOB NO.	3106	CLIENT JOB NO.		DRAWING NO.	JWP-216-22
				REVISION	0

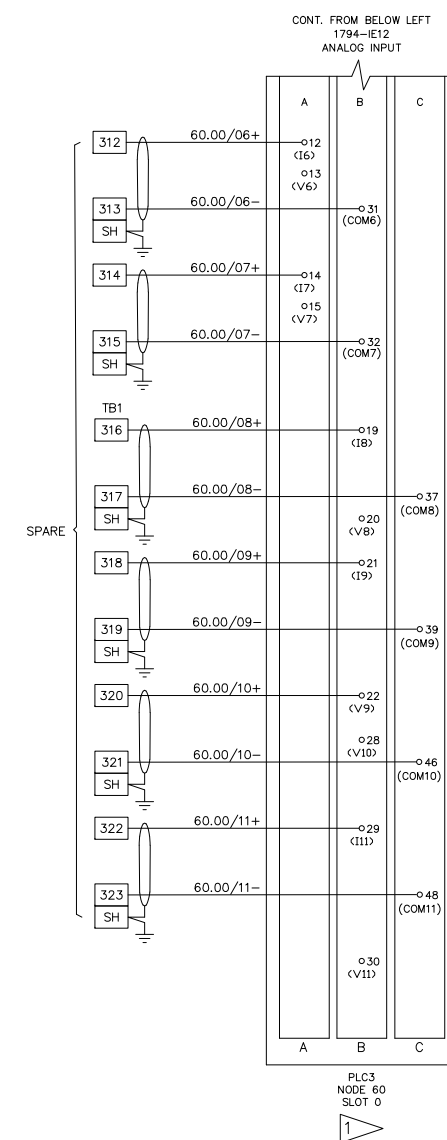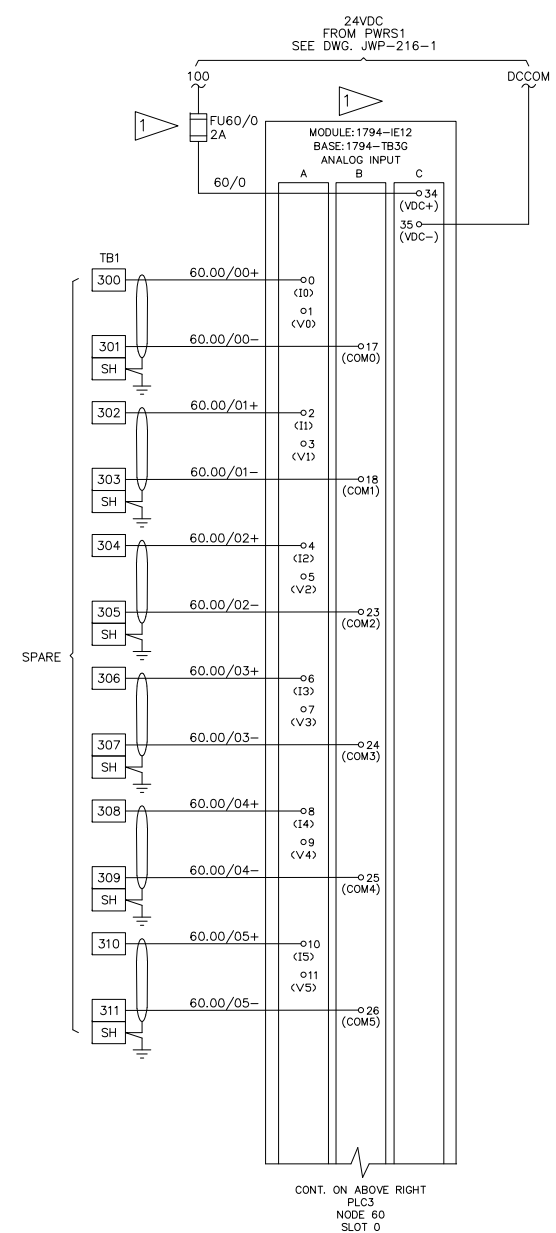

O	8-14-25	PLC3 UPGRADE - PER START-UP					G.
A	3-11-25	PLC3 UPGRADE - FOR APPROVAL					D.
REV.	DATE	DESCRIPTION				BY	APPROVED
SCALE: AS SHOWN	DESIGNED	D. HANDY		APPROVED			
	DRAWN	K. TASTAD	3-11-25	FIVE: 6-216-23 / DATE: 03-11-25			
	CHECKED	D. HANDY		APPROVED			
 JWP CONTROLS, INC.							
POST POINT WWTP UPGRADE CITY OF BELLINGHAM, WASHINGTON							
LOCAL CONTROL PANEL LCP-53020 (RIO-53A) PANEL WIRING & INTERCONNECTION DIAGRAM							
JOB NO.	CLIENT JOB NO.		DRAWING NO.			REVISION	
3106			JWP-216-23			0	

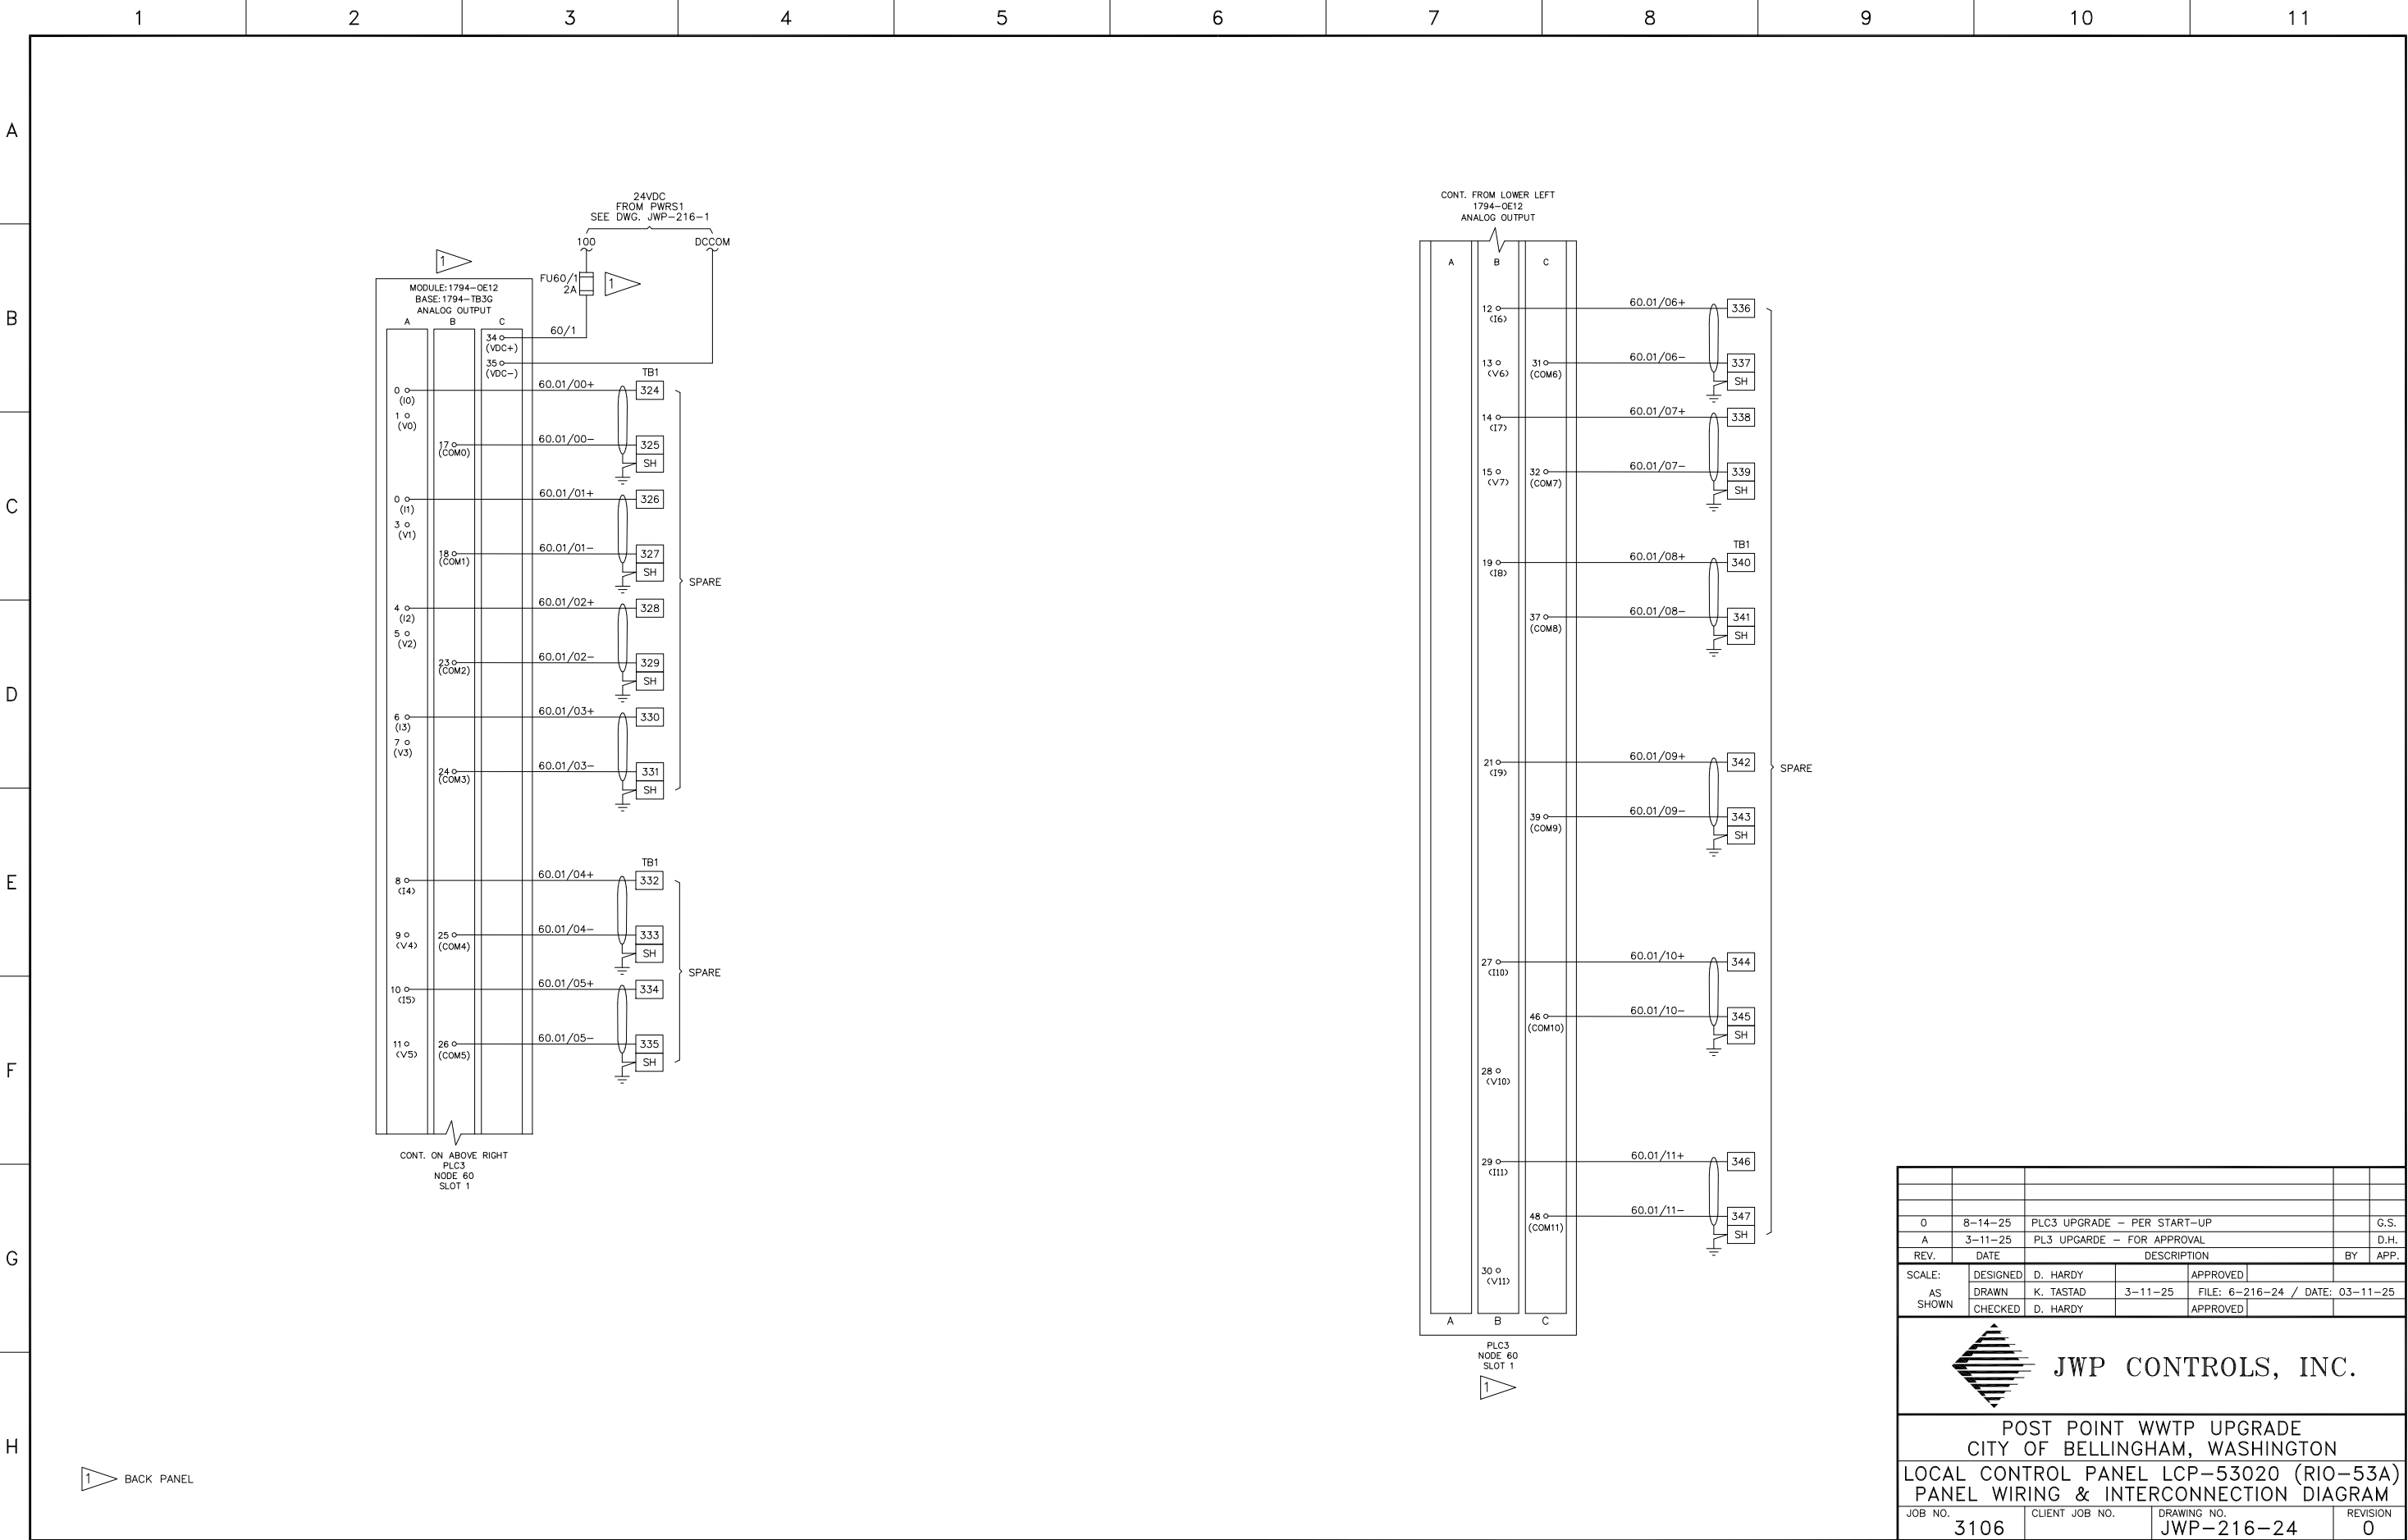

0	8-14-25	PLC3 UPGRADE - PER START-UP			G.S.
A	3-11-25	PL3 UPGARDE - FOR APPROVAL			D.H.
REV.	DATE	DESCRIPTION			BY APP.
SCALE: AS SHOWN	DESIGNED	D. HARDY	APPROVED		
	DRAWN	K. TASTAD	3-11-25	FILE: 6-216-24 / DATE: 03-11-25	
	CHECKED	D. HARDY	APPROVED		
 JWP CONTROLS, INC.					
POST POINT WWTP UPGRADE CITY OF BELLINGHAM, WASHINGTON					
LOCAL CONTROL PANEL LCP-53020 (RIO-53A) PANEL WIRING & INTERCONNECTION DIAGRAM					
JOB NO.	3106	CLIENT JOB NO.	DRAWING NO.	REVISION	
			JWP-216-24	0	

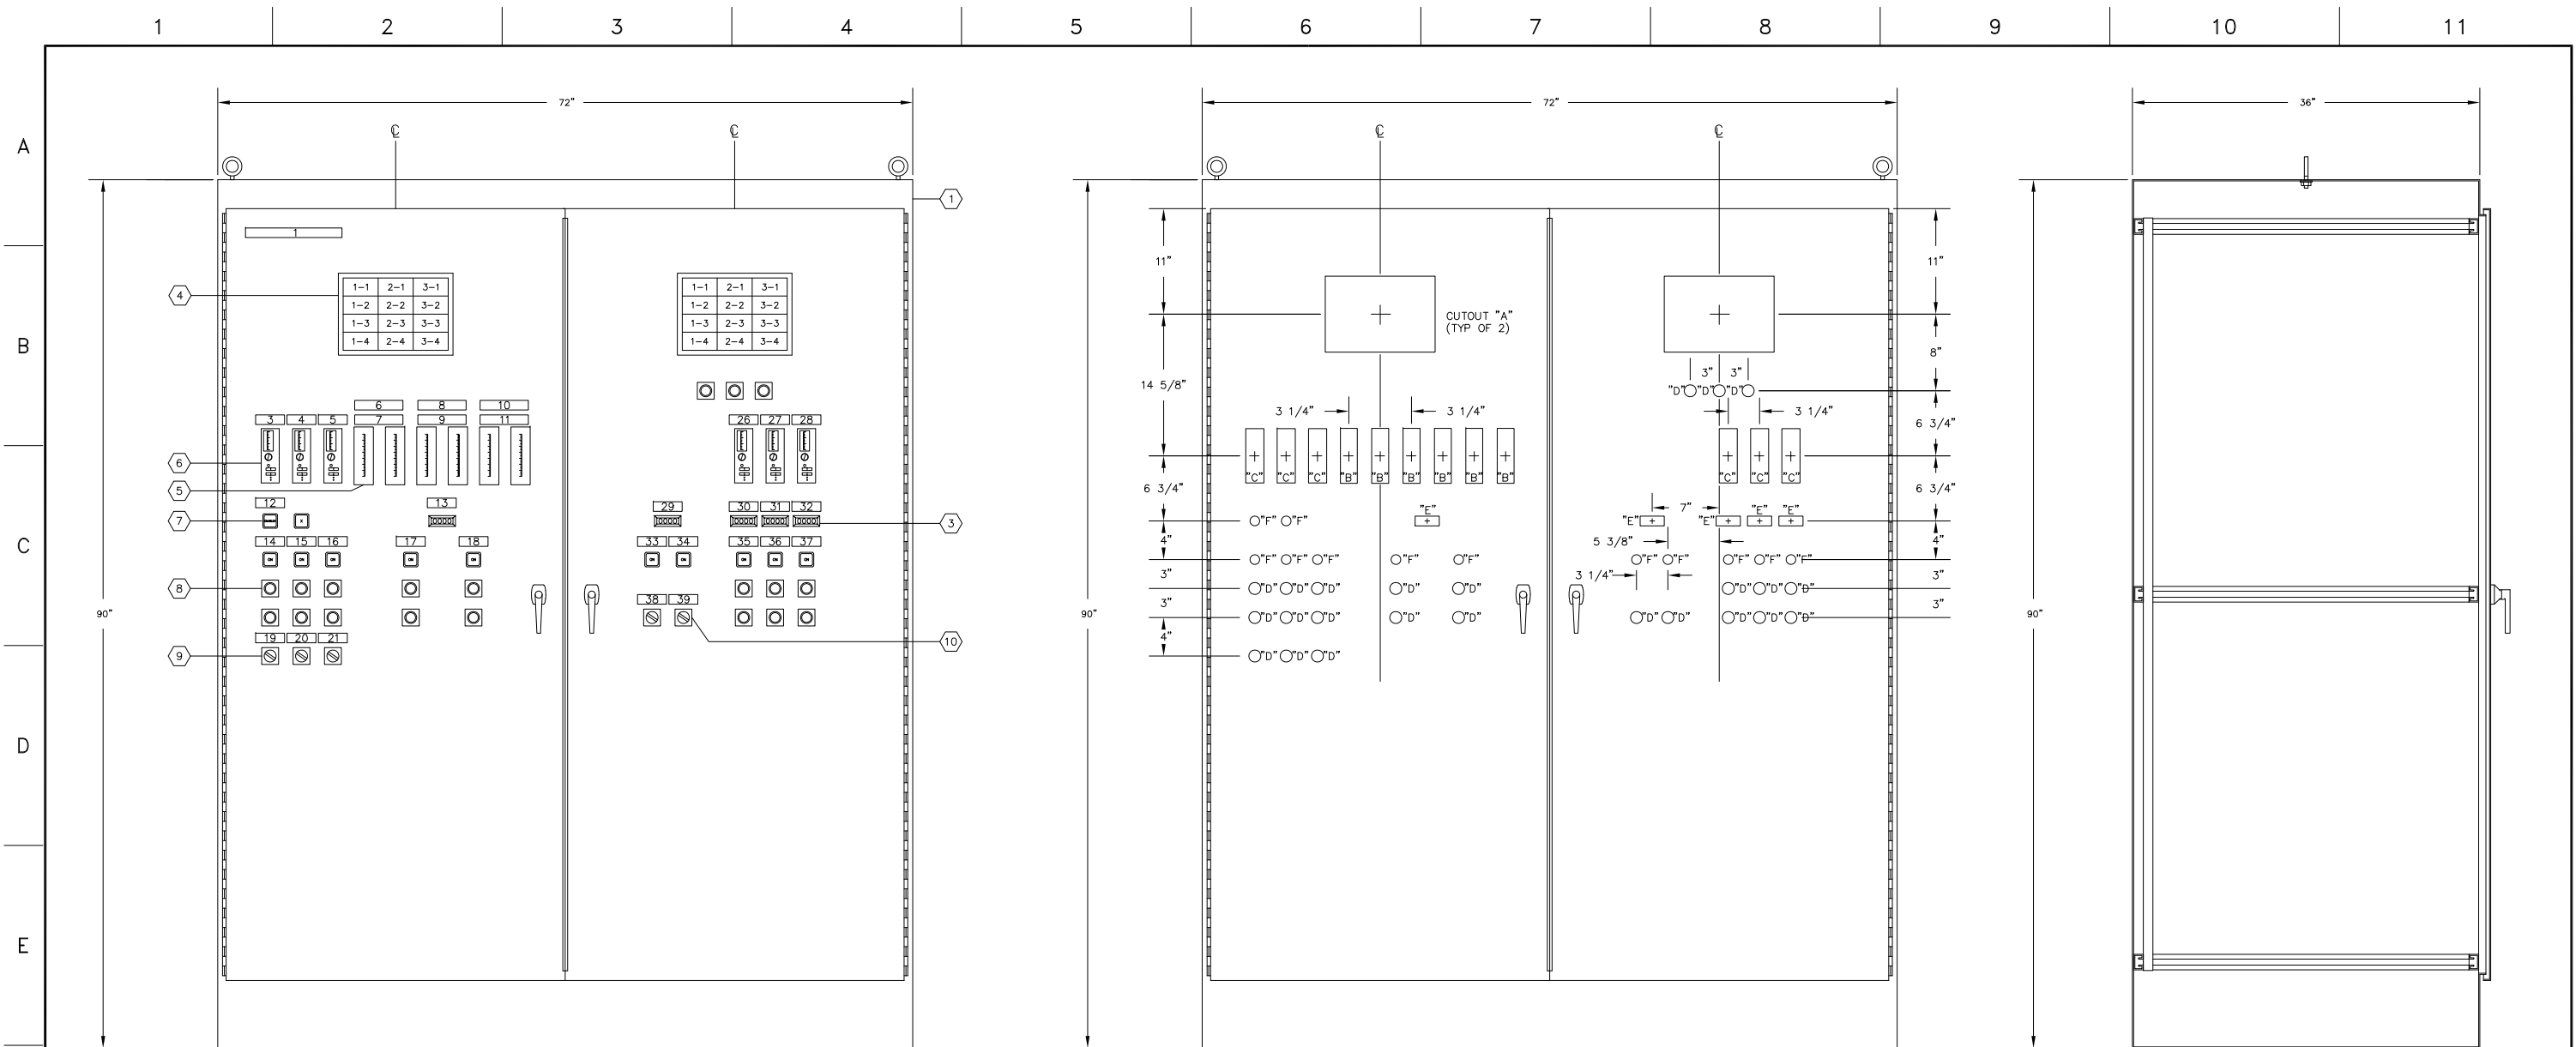


FRONT ELEVATION
SCALE: 1/8" = 1"

FRONT ELEVATION
SCALE: 1/8" = 1"


SIDE ELEVATION
SCALE: 1/8" = 1"

NOTE:
SEE CONTRACT DWG.
910-E-71 FOR
LOCATION


3	8-14-25	PL3 UPGRADE - PER START-UP		G.S.
2	7-20-93	FIELD AS-BUILT	R.C.	P.J.
1	1-10-92	SHOP AS-BUILT	R.C.	P.J.
0	12-11-91	ISSUED FOR CONSTRUCTION	R.C.	P.J.
A	10-23-91	ISSUED FOR APPROVAL	R.C.	
REV.	DATE	DESCRIPTION	BY	APP.
SCALE:	DESIGNED	D. GETTY	APPROVED	
AS SHOWN	DRAWN	R. COOPER	FILE: 6-316-1 / DATE: 07-22-93	
	CHECKED	D. GETTY	APPROVED	
 JWP CONTROLS, INC.				
POST POINT WWTP UPGRADE CITY OF BELLINGHAM, WASHINGTON LOCAL CONTROL PANEL LCP-53020 LAYOUT DETAIL				
JOB NO. 3106	CLIENT JOB NO.	DRAWING NO. JWP-316-1	REVISION 2	

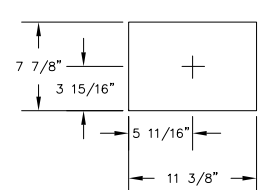


CUTOUT DETAIL "A"
SCALE: 1/8" = 1"

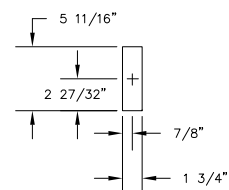


CUTOUT DETAIL "B"
SCALE: 1/8" = 1"

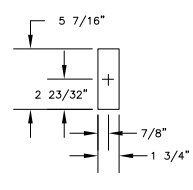


CUTOUT DETAIL "C"
SCALE: 1/8" = 1"

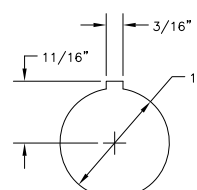

CUTOUT DETAIL "D"
SCALE: FULL

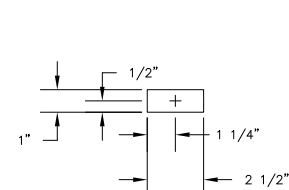

CUTOUT DETAIL "E"
SCALE: 1/4" = 1"

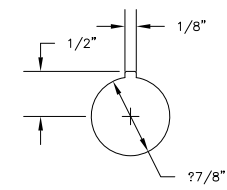

CUTOUT DETAIL "F"
SCALE: FULL